 
 
 
 
 
 
 
 
 
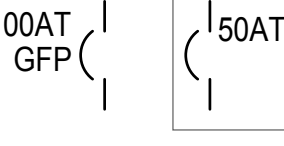
 
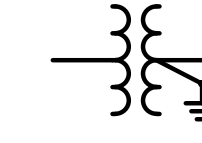
 
 
 
 
 
 


ELECTRICAL SYMBOLS LEGEND

REFERENCE SYMBOLS	POWER SYSTEMS SYMBOLS	CONTROL SYMBOLS
 DETAIL NUMBER SHEET  FLAG NOTE  REVISION TAG  MECHANICAL EQUIPMENT  FAULT CURRENT TAG	 PANELBOARD: SURFACE, FLUSH MOUNTED. DASHED LINE = CLEARANCE (TYPICAL)  ELECTRICAL DISTRIBUTION EQUIPMENT. SEE PLANS FOR TYPE, DIMENSIONS, NAME, ETC. DASHED LINE = CLEARANCE (TYPICAL)  CONNECTION TO EQUIPMENT BY OTHERS  CONNECTION TO MOTOR  DISCONNECT SWITCH, FUSED  DISCONNECT SWITCH  VARIABLE FREQUENCY DRIVE  EMERGENCY POWER OFF BUTTON  GROUND BAR  GROUND ROD  JUNCTION BOX: WALL, FLOOR AND CEILING MTD  RECEPTACLE, DUPLEX: WALL, FLOOR AND CLG MTD; PARALLEL SHADED = HALF-SWITCHED  RECEPTACLE, DUPLEX: WALL MTD ABOVE BACKSPLASH, GFCI-TYPE  RECEPTACLE, DOUBLE DUPLEX: WALL, FLOOR AND CLG MTD; PARALLEL SHADED = HALF-SWITCHED  RECEPTACLE, DOUBLE DUPLEX: WALL MTD ABOVE BACKSPLASH, GFCI-TYPE  RECEPTACLE, SIMPLEX: WALL, FLOOR AND CLG MTD  RECEPTACLE, SIMPLEX: WALL MTD ABOVE BACKSPLASH, GFCI-TYPE  SPECIALTY RECEPTACLE: WALL, FLOOR AND CLG MTD. NEMA TYPE AS INDICATED ON PLANS.  TYPICAL DEVICE ANNOTATIONS: ON ALTERNATE POWER: 700, 701 AND 702 SYSTEMS PER NEC  WEATHERPROOF  GFCI TYPE  FULLY CONTROLLED (NOT HALF-SWITCHED)	 MOTORIZED CONTROL DAMPER THERMOSTAT  WALL SWITCH / LOW VOLTAGE WALL STATION. SUPERSCRIT INDICATES SWITCH TYPE (BELOW). SUBSCRIPT INDICATES SWITCHLEGS / RELAYS CONTROLLED; FOR MULTI-POLE WALL STATIONS, CONTROL FOR EACH POLE SEPARATED BY COMMA (I.E. SWITCHLEGS a AND b CONTROLLED BY ONE POLE, c ANOTHER).  WEATHERPROOF, TYPICAL  WALL SWITCH, LINE VOLTAGE, 1-POLE  WALL SWITCH, LINE VOLTAGE, 3-WAY  WALL SWITCH, LINE VOLTAGE, TIMER SWITCH  LOW VOLTAGE WALL STATION, 1-POLE, ON/OFF  LOW VOLTAGE WALL STATION, 1-POLE, ON/OFF AND RAISE/LOWER  LOW VOLTAGE WALL STATION, 2-POLE, ON/OFF  LOW VOLTAGE WALL STATION, 2-POLE, ON/OFF AND RAISE/LOWER  COMBINATION OCCUPANCY SENSOR SWITCH, WALL-MOUNTED  OCCUPANCY SENSOR: WALL, CLG MTD  PHOTO CELL, CLG MTD  COMBINATION PHOTO CELL / OCCUPANCY SENSOR: WALL, CLG MTD  RISER DIAGRAM SYMBOLS  FUSED SWITCH. AF= FUSE RATING  SWITCH  CONTACTOR/ RELAY - NORMALLY CLOSED  CONTACTOR/ RELAY - NORMALLY OPEN  CONTACTOR COIL  POTENTIAL TRANSFORMER. GROUND PER CODE.  CURRENT TRANSFORMER  DIGITAL METER  UTILITY METER SOCKET WITH METER; PER UTILITY REQUIREMENTS; REMOTE MOUNTED.  CONNECTION TO GROUND  GROUND BAR  PIPE GROUND PER CODE  UFER GROUND PER CODE  SURGE PROTECTION DEVICE
 OR  COMBINATION SMOKE/FIRE DAMPER  FIRE ALARM CONTROL PANEL  FIRE ALARM REMOTE ANUNCIATOR  FIRE ALARM STROBE LIGHT  FIRE ALARM SMOKE DETECTOR  FIRE ALARM COMBINATION SMOKE DETECTOR / CARBON MONOXIDE ALARM	 LOW VOLTAGE SYSTEMS SYMBOLS  PUSHBUTTON. WALL-MOUNTED.  JUNCTION BOX: WALL, FLOOR AND CEILING MTD  COMBINATION RF COAX / PHONE OUTLET WALL, FLOOR AND CEILING MTD  COMBINATION DATA / PHONE OUTLET WALL, FLOOR AND CEILING MTD  DATA OUTLET WALL, FLOOR AND CEILING MTD  PHONE OUTLET WALL, FLOOR AND CEILING MTD  RF COAX CABLE OUTLET WALL, FLOOR AND CEILING MTD  CARD / FOB READER WALL/ MULLION AND BOLLARD MTD  SECURITY DOOR POSITION MONITOR  ELECTRIC STRIKE  KEYPAD WALL/ MULLION AND BOLLARD MTD  CCTV CAMERA LOCATION. WP = WEATHERPROOF F = FUTURE LOCATION; PREWIRE ONLY INTERIOR LOCATIONS; PREWIRE, BOX AND CONDUIT AT EXTERIOR LOCATIONS.  SPEAKER, CEILING MOUNTED	
 BREAK (CONTINUATION)  CAP  STUB DOWN  STUB UP  CONDUIT / CABLING CONCEALED IN CEILING OR WALL  CONDUIT / CABLING CONCEALED UNDERGROUND OR IN CEILING SPACE OF LEVEL BELOW  GROUNDING CONDUCTOR(S) PER CODE  FLEXIBLE CONDUIT		
 SHADING AND/ OR "EM" INDICATES EMERGENCY EGRESS LUMINAIRES  TYPICAL LUMINAIRE ANNOTATIONS: FL1 = LUMINAIRE TYPE 3 = CIRCUIT NUMBER c = SWITCH LEG Z1.2 = CONTROL ZONE		

CODES

2020 NATIONAL ELECTRICAL CODE WITH STATE AND LOCAL AMENDMENTS
2018 WASHINGTON STATE ENERGY CODE - RESIDENTIAL
2018 INTERNATIONAL BUILDING CODE WITH STATE AND LOCAL AMENDMENTS
2018 INTERNATIONAL FIRE CODE WITH STATE AND LOCAL AMENDMENTS
2018 INTERNATIONAL MECHANICAL CODE WITH STATE AND LOCAL AMENDMENTS
2018 INTERNATIONAL PLUMBING CODE WITH STATE AND LOCAL AMENDMENTS
AMERICANS WITH DISABILITIES ACT (ADA)
EVERGREEN SUSTAINABLE DEVELOPMENT STANDARDS (ESDS)
WASHINGTON CITIES ELECTRICAL CODE

DRAWING LIST

E001 COVER SHEET
E002 PROJECT NOTES AND DETAILS
E101 ELECTRICAL SITE PLAN - OVERALL
E102 ELECTRICAL SITE PLAN - SECTION 1
E103 ELECTRICAL SITE PLAN - SECTION 2
E104 ELECTRICAL SITE PLAN - SECTION 3
E105 ELECTRICAL SITE PLAN - SECTION 4
E106 ELECTRICAL SITE PLAN - SECTION 5
E110 SITE LIGHTING PLAN - OVERALL & LUMINAIRE SCHEDULE
E111 SITE LIGHTING PLAN - SECTION 1
E112 SITE LIGHTING PLAN - SECTION 2
E113 SITE LIGHTING PLAN - SECTION 3
E114 SITE LIGHTING PLAN - SECTION 4
E115 SITE LIGHTING PLAN - SECTION 5

ABBREVIATIONS

A, AMP	AMPERES	LBS	POUNDS
AB	ABOVE BACKSPLASH	LCP	LIGHTING CONTROL PANEL
AC	ALTERNATING CURRENT	LCZ	LIGHTING CONTROL ZONE
ACT	ACOUSTICAL CEILING TILE	LF	LINEAL FOOT
ADA	AMERICANS WITH DISABILITIES ACT	LRA	LOCKED ROTOR AMPS
ADJ	ADJUSTABLE	LTG	LIGHTING
AF	AMPERE RATING OF FUSE OR CB FRAME		
AFF	ABOVE FINISHED FLOOR	MAX	MAXIMUM
AFG	ABOVE FINISHED GRADE	MCA	MINIMUM CIRCUIT AMPACITY
AIC	AMPERE INTERRUPTING CAPACITY, AMPERE INTERRUPTING RATING	MED	MEDIUM
	ALUMINUM (ALLOY)	MEP	MECHANICAL, ELECTRICAL & PLUMBING
AL	ALTERNATE		
ALT	APPROXIMATE	MEZZ	MEZZANINE
APPROX	ARCHITECTURAL/ARCHITECT	MIN	MINIMUM OR MINUTE
ARCH	AMPERE RATING OF SWITCH	MISC	MISCELLANEOUS
AS	CB TRIP SETTING (AMPS)	MLO	MAIN LUGS ONLY
AT	AUTOMATIC TRANSFER SWITCH	MNT	MOUNTED
ATS	AUTOMATIC	MOCP	MAXIMUM OVERCURRENT PROTECTION
AUTO	AUXILIARY		
AUX	AMERICAN WIRE GAUGE	N/A	NOT APPLICABLE
AWG		N	NEUTRAL
		NC	NORMALLY CLOSED
BFF	BELOW FINISHED FLOOR	NEC	NATIONAL ELECTRICAL CODE
BHP	BRAKE HORSE POWER	-, NEG	NEGATIVE
BLDG	BUILDING	NEMA	NATIONAL ELECTRICAL MANUFACTURERS' ASSOCIATION
C	CONDUIT	NIC	NOT IN CONTRACT
CB	CIRCUIT BREAKER	NL	NIGHT LIGHT (UNSWITCHED)
CFM	CUBIC FEET PER MINUTE	NO	NORMALLY OPEN
CKT	CIRCUIT	NOM	NOMINAL
CLG	CEILING	NPT	NATIONAL PIPE THREAD
CO	CARBON MONOXIDE	NTS	NOT TO SCALE
CO2	CARBON DIOXIDE		
CONN	CONNECTED	OC	ON CENTER
CT	CURRENT TRANSFORMER	OCC	OCCUPANCY
CU	COPPER	OD	OUTSIDE DIAMETER
		OS	OCCUPANCY SENSOR
dB	DECIBEL	P	POLE
DC	DIRECT CURRENT	PC	PHOTOCELL
* OR DEG.	DEGREE	PERF	PERFORATED
DIA	DIAMETER	Ø OR PH	PHASE
DISC	DISCONNECT	PNL	PANELBOARD
DIST	DISTRIBUTION	POC	POINT OF CONNECTION
DIV	DIVISION	PSF	POUNDS PER SQUARE FOOT
DN	DOWN	PSI	POUNDS PER SQUARE INCH
DP	DISTRIBUTION PANEL		
DWG(S)	DRAWING(S)	QTY	QUANTITY
DZ	DAYLIGHT CONTROL ZONE (LIGHTING)		
EA	EACH	REQ	REQUIRED
EM	EMERGENCY (700 SYSTEM)	RLX	RELOCATE EXISTING
EMT	ELECTRICAL METALLIC TUBING	RM	ROOM
EF	EXHAUST FAN	RMC	RIGID METALLIC CONDUIT
EWC	ELECTRIC WATER COOLER	RNC	RIGID NON-METALLIC CONDUIT (PVC)
EWI	ELECTRIC WATER HEATER	RPM	REVOLUTIONS PER MINUTE
EX	EXISTING/EXISTING TO REMAIN	RTU	ROOF TOP UNIT
		RV	RELIEF VALVE
FA	FIRE ALARM	RX	REMOVE EXISTING
FACP	FIRE ALARM CONTROL PANEL		
FARA	FIRE ALARM REMOTE ANUNCIATOR	SA	SUPPLY AIR
FC	FOOTCANDLES	SD	SMOKE DETECTOR
FF	FINISHED FLOOR	SF	SQUARE FOOT
FLA	FULL LOAD AMPS	SPD	SURGE PROTECTION DEVICE
FLEX	FLEXIBLE	SPEC	SPECIFICATION
FP	FIRE PROTECTION	S/S, OR SS	STAINLESS STEEL
FPM	FEET PER MINUTE	STD	STANDARD
FPS	FEET PER SECOND	SWBD	SWITCHBOARD
FSD	FIRE SMOKE DAMPER	T&P	TEMPERATURE AND PRESSURE
FT	FEET/FOOT		
FOC	FURNISHED BY OWNER	TBD	TO BE DETERMINED
	INSTALLED BY CONTRACTOR	TC	TIMECLOCK
FOIO	FURNISHED BY OWNER	TEL	TELEPHONE
	INSTALLED BY OWNER	TELECOM	TELECOMMUNICATIONS
G, GND	GROUND	TEMP	TEMPERATURE
GALV	GALVANIZED	TOD	TOP OF DECK
GC	GENERAL CONTRACTOR	TOJ	TOP OF JOIST
GFI	GROUND FAULT CIRCUIT INTERRUPTER	T&P	TEMPERATURE & PRESSURE
GFP	GROUND FAULT PROTECTION	TSP	TOTAL STATIC PRESSURE
GRC	GALVANIZED RIGID STEEL CONDUIT	TYP	TYPICAL
H	HEIGHT	UL	UNDERWRITERS LABORATORY
HP	HORSEPOWER	UNO	UNLESS NOTED OTHERWISE
HTR	HEATER	UPS	UNINTERRUPTIBLE POWER SUPPLY
HVAC	HEATING VENTILATING AND AIR CONDITIONING	UTR	UP THROUGH ROOF
HW	HOT WATER	V	VOLT
HZ	HERTZ	VA	VOLT AMPS
		VFD	VARIABLE FREQUENCY DRIVE
ID	INSIDE DIAMETER/DIMENSION	VOL	VOLUME
IESNA	ILLUMINATING ENGINEERING SOCIETY OF NORTH AMERICA	W	WATT
		W/	WITH
IMC	INTERMEDIATE METAL CONDUIT	W/O	WITHOUT
IN	INCH/INCHES	WP	WEATHERPROOF
		WT	WEIGHT
KCMIL	THOUSAND CIRCULAR MILS		
KO	KNOCK OUT	XFR	TRANSFORMER
KW	KILOWATT/KILOWATTS		
KWH	KILOWATT HOUR(S)		
KVA	KILOVOLT AMPS		



192 Nickerson, Suite #300
Seattle, Washington 98109
Phone: 206.285.2966

SMR Architects
117 S. Main St., Suite 400
Seattle, WA 98104

PH: 206.623.1104
FX: 206.623.5285



New Kirkland Heights LLLP
c/o: King County Housing Authority,
General Partner
13310 NE 133rd St.
Kirkland, WA 98034.
CONTRACT #: TC2300131

KIRKLAND HEIGHTS APARTMENTS

13324 NE 132nd St.,
Kirkland, WA 98034

SITE ELECTRICAL INFRASTRUCTURE
BID SET



REVISIONS / NOTES		
NO	DATE	DESCRIPTION
1	5.19.23	BID ADDENDUM 2

DPD STAMP

TITLE

COVER SHEET

PERMIT #	
DRAWN	RA, JF
CHECKED	GL
ISSUE DATE	04/14/2023
JOB NO.	22014
SHEET NO.:	

E001

ENERGY CODE NOTES


- SEE THE LUMINAIRE SCHEDULE, AND THE LIGHTING PLANS FOR LIGHTING AND LIGHTING CONTROL REQUIREMENTS. SYSTEMS SHALL MEET THE REQUIREMENTS OF C405.2 AND C405.4.
- OCCUPANCY SENSORS SHALL FAIL ON AND AUTOMATICALLY TURN OFF LUMINAIRES IN THEIR COVERAGE AREA WITHIN 30 MINUTES OF ALL OCCUPANTS LEAVING THE SPACE UNLESS NOTED OTHERWISE ON THE PLANS. SEE LIGHTING CONTROL SCHEDULES FOR ADDITIONAL FUNCTIONALITY REQUIREMENTS.
- EXTERIOR LUMINAIRES THAT ARE INTENDED TO LIGHT THE BUILDING FAÇADE OR LANDSCAPE SHALL HAVE CONTROLS THAT AUTOMATICALLY SHUT OFF THE LIGHTING AS A FUNCTION OF DAWN / DUSK AND A SET OPENING AND CLOSING TIME.
- THE SITE LIGHTING SHALL BE COMMISSIONED PER THE REQUIREMENTS OF SECTION C408 AND AS PER ADDITIONAL COMMISSIONING REQUIREMENTS FOR PROJECT - SEE DIVISION 01 AND DIVISION 26 SPECIFICATIONS, COMMISSIONING NOTES THIS DRAWING AND PROJECT DRAWINGS FOR REQUIREMENTS.

DEMOLITION NOTES


- THE EXISTING BUILDINGS ON THE CAMPUS ARE TO REMAIN MOSTLY OCCUPIED DURING CONSTRUCTION. ANY ELECTRICAL WORK THAT WILL REQUIRE THE TEMPORARY INTERRUPTION OF THE POWER TO ANY PORTION OF THE BUILDING(S) SHALL BE PRE-SCHEDULED WITH THE OWNER AND ARCHITECT AT LEAST FIFTEEN WORKING DAYS PRIOR TO STARTING SAID WORK. THE CONTRACTOR SHALL NOT INTERRUPT POWER TO ANY PORTION OF THE BUILDING WITHOUT PRIOR THE WRITTEN CONSENT OF THE OWNER.
 - ALL EXISTING UTILITY SERVICES (POWER, TELEPHONE, CABLE TELEVISION) ON THE CAMPUS WILL BE REPLACED WITH NEW INFRASTRUCTURE. ALL EXISTING INFRASTRUCTURE WILL BE DEMOLISHED OR DISCONNECTED AND ABANDONED IN PLACE WHERE ALLOWED BY UTILITY PROVIDERS, CIVIL, ARCHITECT, OWNER, ETC. ALL UTILITY WORK MUST BE FULLY COORDINATED WITH ALL PROVIDERS PRIOR TO THE START OF ANY DEMOLITION OR RELOCATION OF EXISTING FACILITIES.
- CONTRACTORS MUST COORDINATE WITH UTILITY PROVIDERS FOR ANY AND ALL REQUIRED INSPECTIONS OF REVISED OR NEW UTILITY INFRASTRUCTURE.
- PLEASE NOTE, ALL INFORMATION SHOWN IN REGARDS TO THE EXISTING SYSTEMS AND INSTALLATION WAS TAKEN FROM AVAILABLE RESOURCES. THE CONTRACTOR SHALL VISIT THE SITE PRIOR TO SUBMISSION OF BID AND FIELD VERIFY ACTUAL CONDITIONS RELATED TO THE SCOPE OF WORK FOR THIS PROJECT AND SHALL INCLUDE ALL WORK REQUIRED TO FULFILL THE PROJECT SCOPE BASED ON THE ACTUAL EXISTING CONDITIONS IN THEIR BID. INFORM ARCHITECT AND ENGINEER OF CONFLICTS.
 - EXISTING CIRCUITING, WHERE SHOWN, IS BASED ON AVAILABLE AS-BUILT DRAWINGS. THE CONTRACTOR SHALL FIELD VERIFY EXISTING INSTALLATIONS.
 - FOR EXISTING EQUIPMENT TO BE DEMOLISHED, REMOVE ALL ASSOCIATED ELECTRICAL DISCONNECTS, CONDUIT, CONDUCTORS, AND CABLING BACK TO PANELBOARD FOR EQUIPMENT ON DEDICATED CIRCUITS. WHERE ADDITIONAL EQUIPMENT TO REMAIN OR BE REPLACED SHARES A CIRCUIT WITH EQUIPMENT TO BE DEMOLISHED, REMOVE ELECTRICAL DISCONNECT AND WIRING ASSOCIATED WITH EQUIPMENT TO BE DEMOLISHED AND REWORK CIRCUIT WIRING AS REQUIRED TO MAINTAIN POWER TO EQUIPMENT TO REMAIN OR BE REPLACED.
 - WHERE RENOVATION WORK INTERFERES WITH EXISTING CIRCUITS OR EQUIPMENT NOT TO BE DEMOLISHED, REWORK OR RELOCATE EXISTING CIRCUITS AND EQUIPMENT AS REQUIRED TO MAINTAIN POWER TO THEM. REFER ALL CONFLICTS TO THE ARCHITECT AND ENGINEER.
 - REMOVE EXISTING BRANCH CIRCUIT CONDUCTORS, CONDUITS AND CABLING ASSOCIATED WITH EXISTING EQUIPMENT AND DEVICES TO BE DEMOLISHED BACK TO THE NEAREST ACTIVE DEVICE THAT IS TO REMAIN. MAKE-SAFE CONDUCTORS AND CAP-OFF CONDUIT AS REQUIRED.
 - WHERE EXISTING BRANCH CIRCUITS ARE TO BE RE-USED THE CONDUCTORS, CONDUIT OR CABLES OF THE ORIGINAL CIRCUIT ARE TO REMAIN AND BE RE-USED IF POSSIBLE. DOWNSTREAM BRANCH CIRCUIT CONDUCTORS, CONDUIT OR CABLES SERVING EXISTING TO BE DEMOLISHED EQUIPMENT OR DEVICES ARE TO BE REMOVED. THE CONTRACTOR SHALL VERIFY THAT EXISTING CONDUCTORS TO BE RE-USED ARE IN GOOD CONDITION AND RATED FOR 90-DEGREES C.
 - ALL REMOVED ELECTRICAL MATERIALS NOT TO BE RE-USED SHALL BECOME THE PROPERTY OF THE ELECTRICAL CONTRACTOR AND SHALL BE REMOVED FROM THE JOB SITE.
 - COORDINATE STORAGE LOCATION AND PROTECTION OF EQUIPMENT TO BE RE-USED WITH THE OWNER.
 - DAMAGE TO EQUIPMENT, DEVICES, ETC TO REMAIN CAUSED BY THE CONTRACTOR SHALL E REPLACED, REPAIRED AND RESTORED BY THE CONTRACTOR AT NO EXPENSE TO THE OWNER. WORK SHALL BE COMPLETED TO THE COMPLETE SATISFACTION OF THE OWNER.

GENERAL PROJECT NOTES


- THESE PLANS ARE SCHEMATIC AND DO NOT SHOW EXACT ROUTING, DEVICE LOCATIONS, ETC. THE ELECTRICAL, LOW VOLTAGE AND FIRE ALARM CONTRACTORS SHALL COORDINATE WITH ALL OTHER TRADES AND PROVIDE COMPLETE AND FULLY OPERATIONAL AND COORDINATED ELECTRICAL AND FIRE ALARM SYSTEMS THAT MEET ALL REQUIREMENTS OF THE OWNER, CODE AND THE LOCAL AHJ AND THE CONTRACT DOCUMENTS.
- MATERIALS, METHODS AND INSTALLATION SHALL COMPLY WITH THE PROVISIONS OF THE LATEST EDITION (WITH STATE AND LOCAL AMENDMENTS) OF THE NATIONAL ELECTRICAL CODE, WASHINGTON STATE ENERGY CODE, INTERNATIONAL BUILDING CODE, INTERNATIONAL FIRE CODE, INTERNATIONAL MECHANICAL CODE, UNIFORM PLUMBING CODE, THE AMERICANS WITH DISABILITY ACT AND LOCAL CODES AND ORDINANCES.
- CONFIRM ALL DEVICE AND EQUIPMENT LOCATIONS AND QUANTITIES WITH THE OWNER AND ARCHITECT PRIOR TO THE START OF CONSTRUCTION.
- CONTRACTORS TO MAINTAIN THE FIRE RATING OF ANY FIRE-RATED WALLS AND FLOORS. ALL FLOOR PENETRATIONS TO BE FINISHED TO A SMOOTH SURFACE.
- INSTALL ALL EQUIPMENT PER CODE AND MANUFACTURER'S INSTRUCTIONS. THESE DRAWINGS ARE DIAGRAMMATIC. REFER TO THE MECHANICAL/PLUMBING EQUIPMENT COORDINATION SCHEDULE FOR CONNECTION REQUIREMENTS FOR SPECIFIC MECHANICAL AND PLUMBING EQUIPMENT. SEE THE PANEL SCHEDULES AND FEEDER AND BRANCH CIRCUIT SCHEDULES FOR CIRCUIT SIZES.
- ALL ELECTRICAL AND LOW VOLTAGE SYSTEM DEVICES AND EQUIPMENT (LUMINAIRES, CONDUIT AND CABLING, ETC) SHALL BE INDEPENDENTLY SUPPORTED (I.E. DO NOT SUPPORT LUMINAIRES FROM MECHANICAL EQUIPMENT, ETC). PROVIDE SUPPORTS PER CODE AND AHJ REQUIREMENTS.
- ALL UTILITY INFRASTRUCTURE (POWER AND TELECOM) SHALL MEET THE UTILITY SERVICE PROVIDERS' REQUIREMENTS.
- ALL NEW RACEWAYS AND CABLING SHALL BE INSTALLED CONCEALED WHEREVER POSSIBLE. AT OPEN CEILING AREAS, CONTRACTOR MUST PROVIDE CONDUCTORS / CABLING IN CONDUIT. COORDINATE THE ROUTING OF THE CONDUIT AT OPEN CEILING AREAS WITH THE ARCHITECT. ALL CONDUIT AND CABLING SHALL BE INSTALLED PARALLEL WITH BUILDING LINES. THE CONTRACTORS SHALL COORDINATE WITH THE CEILING TYPES IN ALL ROOMS AND ENSURE THAT ALL JUNCTION BOXES ARE ACCESSIBLE AFTER THE WORK OF ALL TRADES IS COMPLETE. JUNCTION BOXES SHALL NOT BE LOCATED ON HARD CEILINGS OR IN WALLS IN "FRONT OF HOUSE" SPACES WITHOUT PRIOR APPROVAL FROM ARCHITECT.
- COORDINATE CONDUIT AND CABLING ROUTING WITH ALL OTHER TRADES PRIOR TO INSTALLATION TO AVOID CONFLICTS. ROUTE CONDUIT AS TO MINIMIZE PENETRATIONS THROUGH PARTITIONS.
- COORDINATE THE EXACT LOCATIONS OF CEILING MOUNTED DEVICES WITH ALL OTHER TRADES. OCCUPANCY / VACANCY SENSORS SHALL BE INSTALLED AT LEAST 8"FT OR THE MANUFACTURER'S RECOMMENDED DISTANCE FROM ALL HVAC EXHAUST DIFFUSERS. LOCATE PHOTO CELLS PER MANUFACTURER'S INSTRUCTIONS.
- COORDINATE THE LOCATIONS OF ALL WALL-MOUNTED DEVICES (OCCUPANCY SENSOR SWITCHES, LOW VOLTAGE WALL STATIONS, LINE VOLTAGE SWITCHES, THERMOSTATS, ETC) WITH LOCATIONS AND SWINGS OF DOORS. DO NOT LOCATE DEVICES SUCH THAT THEY WILL BE BEHIND ANY DOOR WHEN THAT DOOR IS OPEN WITHOUT PRIOR APPROVAL OF THE ARCHITECT.
- BACK-TO-BACK DEVICES ARE NOT ALLOWED; INSTALL IN SEPARATE STUD CAVITIES.
- THE ELECTRICAL CONTRACTOR SHALL PERFORM SHORT-CIRCUIT / FAULT CURRENT AND ARC FLASH STUDIES FOR THE PROJECT PER THE ACTUAL INTENDED INSTALLATION (FINAL GEAR SELECTION, ACTUAL FEEDER LENGTHS, ETC). STUDIES SHALL BE SUBMITTED TO THE ENGINEER WITH THE GEAR SUBMITTAL FOR REVIEW. FINAL STUDIES SHALL BE STAMPED BY AN ELECTRICAL ENGINEER CURRENTLY REGISTERED IN THE STATE OF WASHINGTON AND SHALL BE SUBMITTED TO THE LOCAL AHJ. THE ELECTRICAL CONTRACTOR SHALL PROVIDE ARC FLASH LABELS ON ALL ELECTRICAL DISTRIBUTION EQUIPMENT PER CODE AND AHJ REQUIREMENTS. SEE THE SPECIFICATION FOR ADDITIONAL REQUIREMENTS.
- LIGHTING CONTROL COORDINATION MEETINGS: THE ELECTRICAL CONTRACTOR SHALL COORDINATE A LIGHTING CONTROL COORDINATION MEETING WITH THE OWNER, ARCHITECT, GENERAL CONTRACTOR, ELECTRICAL CONTRACTOR AND AN AUTHORIZED SERVICE REPRESENTATIVE OF THE INTENDED LIGHTING CONTROL SYSTEM FOR THE PROJECT TO DISCUSS THE LIGHTING CONTROL INTENT FOR THE PROJECT AND INTEGRATION OF THE LIGHTING CONTROL SYSTEM. THIS MEETING SHALL OCCUR AT LEAST TEN (10) WORKING DAYS PRIOR TO SUBMITTING THE LIGHTING CONTROL SUBMITTAL; THE LIGHTING CONTROL SUBMITTAL SHALL REFLECT THE DECISIONS MADE DURING THIS MEETING.
- THE ELECTRICAL CONTRACTOR SHALL MARK LOCATIONS OF ALL DEVICES FOR POWER AND LOW VOLTAGE SYSTEMS (RECEPTACLES, TELECOM OUTLETS, CATV OUTLETS, FLOORBOXES, ETC) THROUGHOUT THE PROJECT FOR THE OWNER AND ARCHITECT TO REVIEW AND APPROVE PRIOR TO WIRING AND INSTALLATION OF DEVICES/ INFRASTRUCTURE OF DEVICES. WHEN REQUESTED BY THE ARCHITECT AND OWNER, THE ELECTRICAL CONTRACTOR SHALL RELOCATE DEVICES AND EQUIPMENT UP TO SIX (6) FEET IN ANY DIRECTION AT NO COST TO THE PROJECT.
- THE ELECTRICAL CONTRACTOR SHALL MAKE ALL REQUIRED SUBMISSIONS TO THE AUTHORITIES HAVING JURISDICTION FOR PERMITS AND APPROVAL OF ALL ELECTRICAL SYSTEMS AND SHALL PAY ALL FEES ASSOCIATED WITH THESE SUBMISSIONS AND OBTAINING THE REQUIRED PERMIT(S). PROVIDE A COPY OF THE FINAL APPROVED DRAWINGS WITH THE LOCAL AHJ'S APPROVAL STAMP TO THE OWNER FOR THEIR RECORDS.
- ALL LOW VOLTAGE SYSTEMS, INCLUDING FIRE ALARM, ARE DESIGN BUILD. ANY DEVICES AND EQUIPMENT INDICATED ON THESE PLANS ARE PRELIMINARY FOR SPACE PLANNING PURPOSES ONLY. SEE LOW VOLTAGE NOTES THIS DRAWING, PRELIMINARY SYSTEMS PLANS, AND PERFORMANCE SPECIFICATIONS FOR INFORMATION AND REQUIREMENTS.
 - FIRE ALARM SYSTEMS ARE TO BE DESIGNED, PERMITTED AND INSTALLED BY A FIRE ALARM CONTRACTOR HIRED UNDER THE SCOPE OF THIS PROJECT.
 - ALL OTHER LOW VOLTAGE SYSTEMS (CATV, TELECOM, ETC) ARE TO BE DESIGNED AND INSTALLED BY A LOW VOLTAGE DESIGN-BUILD CONTRACTOR HIRED BY THE ELECTRICAL CONTRACTOR.
 - THE ELECTRICAL CONTRACTOR IS TO PROVIDE ALL INFRASTRUCTURE (LINE VOLTAGE POWER, CONDUITS WITH PULLSTRINGS, BACKBOXES, EQUIPMENT RACKS, ETC) FOR THESE SYSTEMS. LOW VOLTAGE DEVICES SHOWN IN THIS BID SET ARE FOR BIDDING PURPOSES ONLY. THE ELECTRICAL CONTRACTOR SHALL CONFIRM ACTUAL DEVICE LOCATIONS, QUANTITIES, AND REQUIREMENTS WITH THE OWNER'S SYSTEM INSTALLERS AT THE START OF CONSTRUCTION.
 - THE ELECTRICAL CONTRACTOR SHALL COORDINATE WITH ALL TELECOM UTILITY SERVICE PROVIDERS TO BRING TELECOM SERVICE TO THE BUILDING.

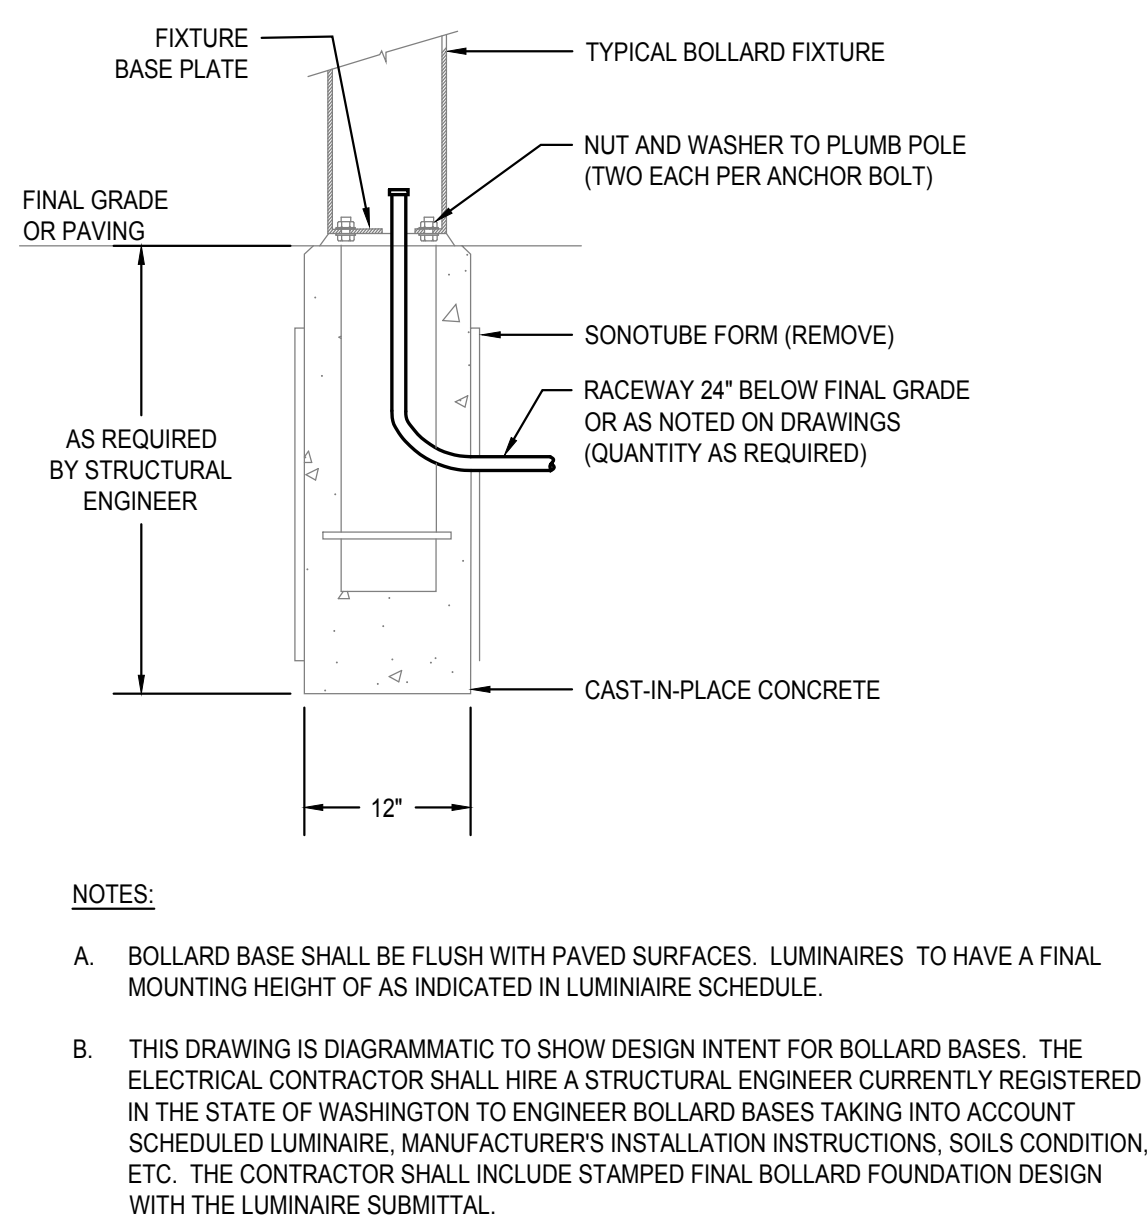

1 BOLLARD BASE DETAIL
N.T.S.

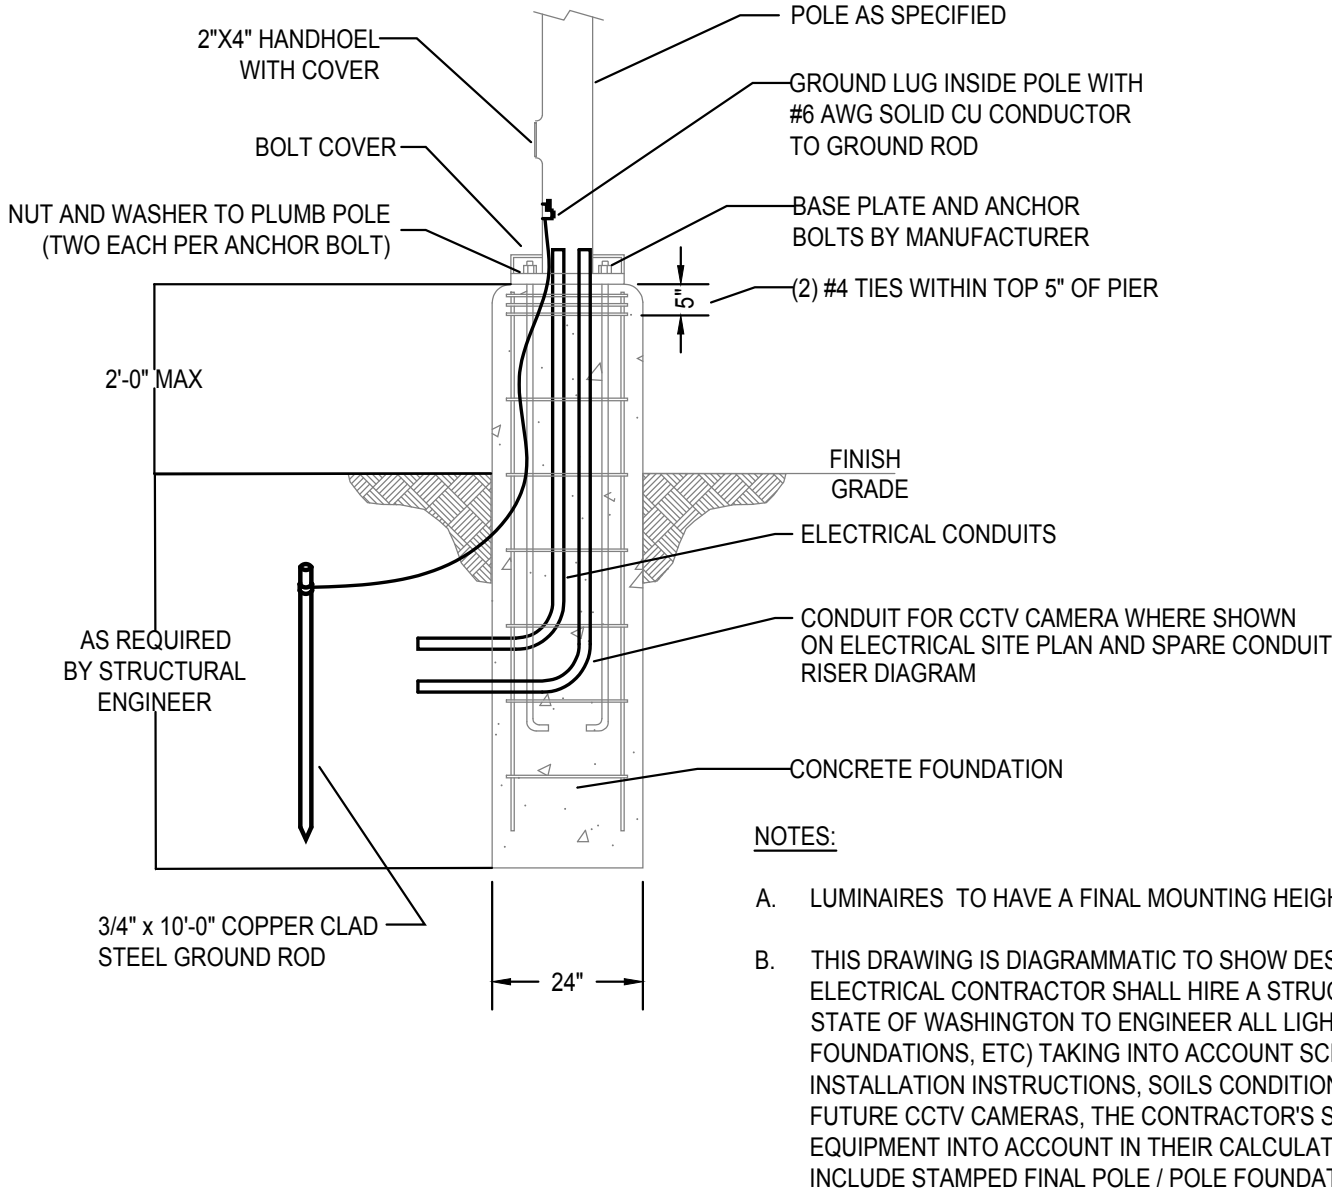

2 POLE-MOUNTED LUMINAIRE POLE BASE DETAIL
N.T.S.

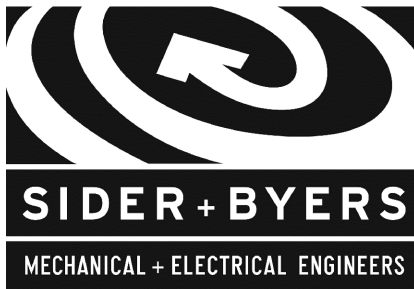

192 Nickerson, Suite #300
Seattle, Washington 98109
Phone: 206.285.2966

SMR Architects
117 S. Main St., Suite 400
Seattle, WA 98104

PH: 206.623.1104
FX: 206.623.5285



New Kirkland Heights LLLP
c/o: King County Housing Authority,
General Partner
13310 NE 133rd St.
Kirkland, WA 98034
CONTRACT #: TC2300131

KIRKLAND HEIGHTS APARTMENTS

13324 NE 132nd St.,
Kirkland, WA 98034

SITE ELECTRICAL INFRASTRUCTURE
BID SET



REVISIONS / NOTES		
NO	DATE	DESCRIPTION
1	5.19.23	BID ADDENDUM 2



DPD STAMP

TITLE

PROJECT NOTES AND DETAILS

PERMIT #	
DRAWN	RA, JF
CHECKED	GL
ISSUE DATE	04/14/2023
JOB NO.	22014
SHEET NO.:	

E002

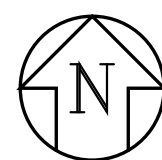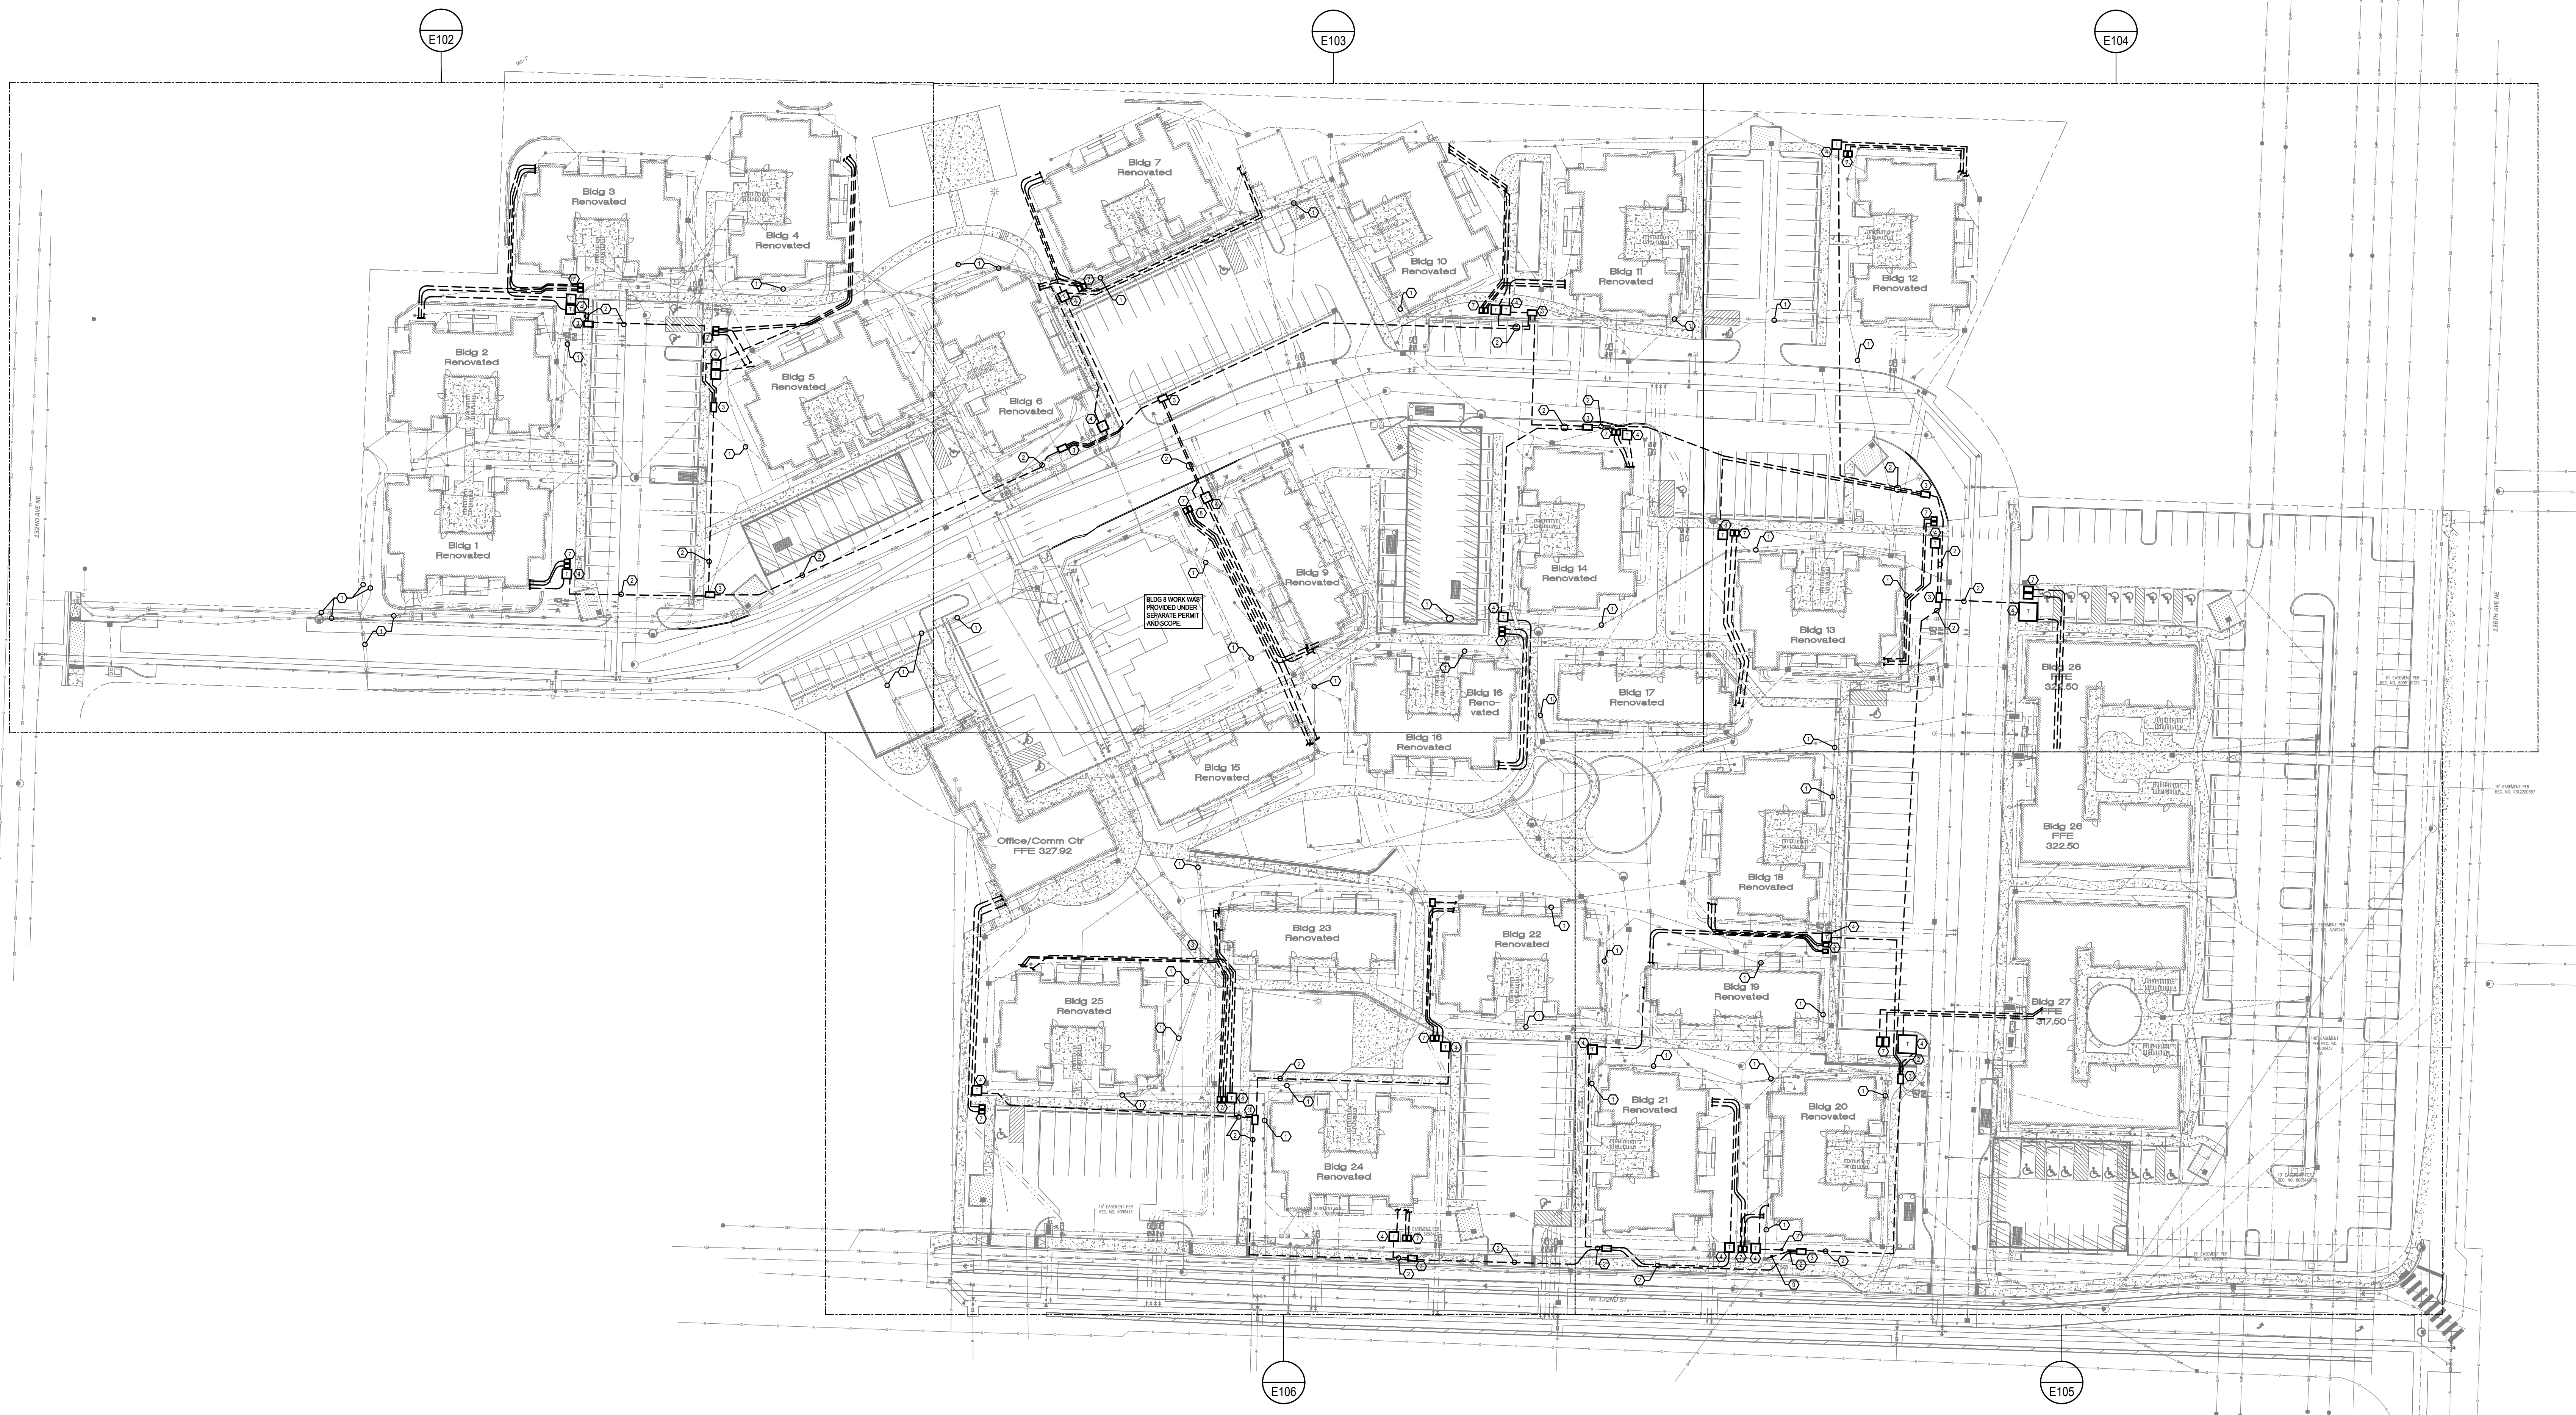

ELECTRICAL SITE PLAN - OVERALL
SCALE: 1"=40'-0"


GENERAL NOTES:

- CONTRACTOR(S) TO PROVIDE AND EXECUTE LOCATES AND VERIFY ALL EXISTING UTILITY CONDITIONS PRIOR TO SITE ALTERATIONS.
- COORDINATE ALL LOCATIONS AND ROUTING OF NEW UTILITY ELEMENTS WITH CIVIL AND ALL UTILITY PROVIDERS PRIOR TO ANY SITE WORK AND ROUGH-IN.
- ALL TRENCHING AND BACKFILL NEEDED FOR ELECTRICAL SCOPE IS TO BE PROVIDED BY THE GENERAL CONTRACTOR.
- ALL UTILITY TRANSFORMERS ARE TO BE PLACED IN SITE LOCATIONS THAT PROVIDE A FLAT GRADED SURFACE WITH 10-FEET OF CLEARANCE TO ANY COMBUSTIBLE CONSTRUCTION ELEMENTS AND MEETING PSE REQUIREMENTS FOR WORKING AREA.
- CONDUIT ROUTING TO BUILDING FOR REFERENCE ONLY. SEE INDIVIDUAL BUILDING SITE PLANS FOR ADDITIONAL INFORMATION.

FLAG NOTES (X):

- ALL EXISTING POWER AND TELECOM UTILITIES ARE TO BE REPLACED WITH NEW INFRASTRUCTURE. EXISTING INFRASTRUCTURE TO BE DISCONNECTED AND ABANDONED IN PLACE WHERE POSSIBLE OR DEMOLISHED WHERE CONFLICTS EXIST WITH NEW SITE INFRASTRUCTURE. THE GENERAL AND ELECTRICAL CONTRACTORS ARE TO COORDINATE DIRECTLY WITH ALL UTILITY PROVIDERS TO ESTABLISH A SCHEDULE AND SEQUENCING OF SERVICE DISCONNECTS AND INSTALLATION OF NEW INFRASTRUCTURE THROUGHOUT SITE.
- NEW UNDERGROUND PRIMARY POWER INFRASTRUCTURE BY PUGET SOUND ENERGY (PSE). PRIMARY POWER TO BE RUN IN A JOINT UTILITY TRENCH WITH NEW TELECOM INFRASTRUCTURE. PSE TO PROVIDE ALL CONDUIT, J-BOXES, TRANSFORMERS, ETC. FOR PRIMARY POWER INFRASTRUCTURE. GENERAL AND ELECTRICAL CONTRACTOR TO PROVIDE TRENCHING PER PSE AND TELECOMMUNICATION PROVIDERS REQUIREMENTS.
- NEW IN-GRADE PRIMARY POWER JUNCTION BOX PROVIDED BY PSE.
- NEW PAD MOUNTED TRANSFORMER FOR INDIVIDUAL BUILDING SERVICE CONNECTION(S). PSE TO PROVIDE AND INSTALL TRANSFORMER AND MAKE ALL CONNECTIONS. SEE INDIVIDUAL BUILDING PLAN SETS FOR LOCATIONS AND ADDITIONAL INSTALLATION REQUIREMENTS.
- NOT USED.
- NOT USED.
- NEW RECESSED IN-GRADE JUNCTION BOX FOR TELECOM. SERVICE CONNECTION(S) TO THE INDIVIDUAL BUILDINGS. SEE INDIVIDUAL BUILDING PLAN SETS FOR LOCATIONS AND ADDITIONAL INSTALLATION REQUIREMENTS.
- EXISTING PSE TRANSFORMER TO REMAIN. COORDINATE NEW PRIMARY AND SECONDARY CONNECTIONS WITH PSE. SEE INDIVIDUAL BUILDING PLAN SETS FOR LOCATION AND ADDITIONAL INSTALLATION REQUIREMENTS.
- PROVIDE PRIMARY SERVICE FEEDERS FROM THE EXISTING PSE POWER POLE TO THE NEW J-BOX PER PSE REQUIREMENTS AND STANDARDS.

ALL INFORMATION SHOWN IN REGARDS TO THE EXISTING SYSTEMS AND INSTALLATION WAS TAKEN FROM AVAILABLE RESOURCES. THE CONTRACTORS SHALL VISIT THE SITE PRIOR TO SUBMISSION OF BIDS AND FIELD VERIFY ACTUAL CONDITIONS RELATED TO THE SCOPE OF WORK FOR THIS PROJECT AND SHALL INCLUDE ALL WORK REQUIRED TO FULFILL THE PROJECT SCOPE BASED ON THE ACTUAL EXISTING CONDITIONS IN THEIR BID. INFORM ARCHITECT AND ENGINEER OF CONFLICTS.

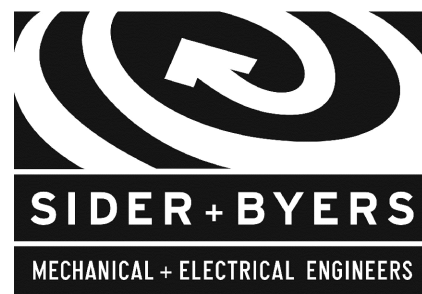

192 Nickerson, Suite #300
Seattle, Washington 98109
Phone: 206.285.2966

SMR Architects
117 S. Main St., Suite 400
Seattle, WA 98104

PH: 206.623.1104
FX: 206.623.5285



New Kirkland Heights LLLP
c/o: King County Housing Authority,
General Partner
13310 NE 133rd St.
Kirkland, WA 98034.
CONTRACT #: TC2300131

**KIRKLAND
HEIGHTS
APARTMENTS**

13324 NE 132nd St.,
Kirkland, WA 98034

**SITE ELECTRICAL
INFRASTRUCTURE
BID SET**





REVISIONS / NOTES		
NO	DATE	DESCRIPTION
1	5.19.23	BID ADDENDUM 2

DPD STAMP

**ELECTRICAL
SITE PLAN -
OVERALL**

PERMIT #	
DRAWN	RA, JF
CHECKED	GL
ISSUE DATE	04/14/2023
JOB NO.	22014
SHEET NO.:	

E101

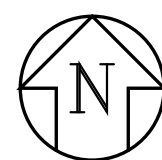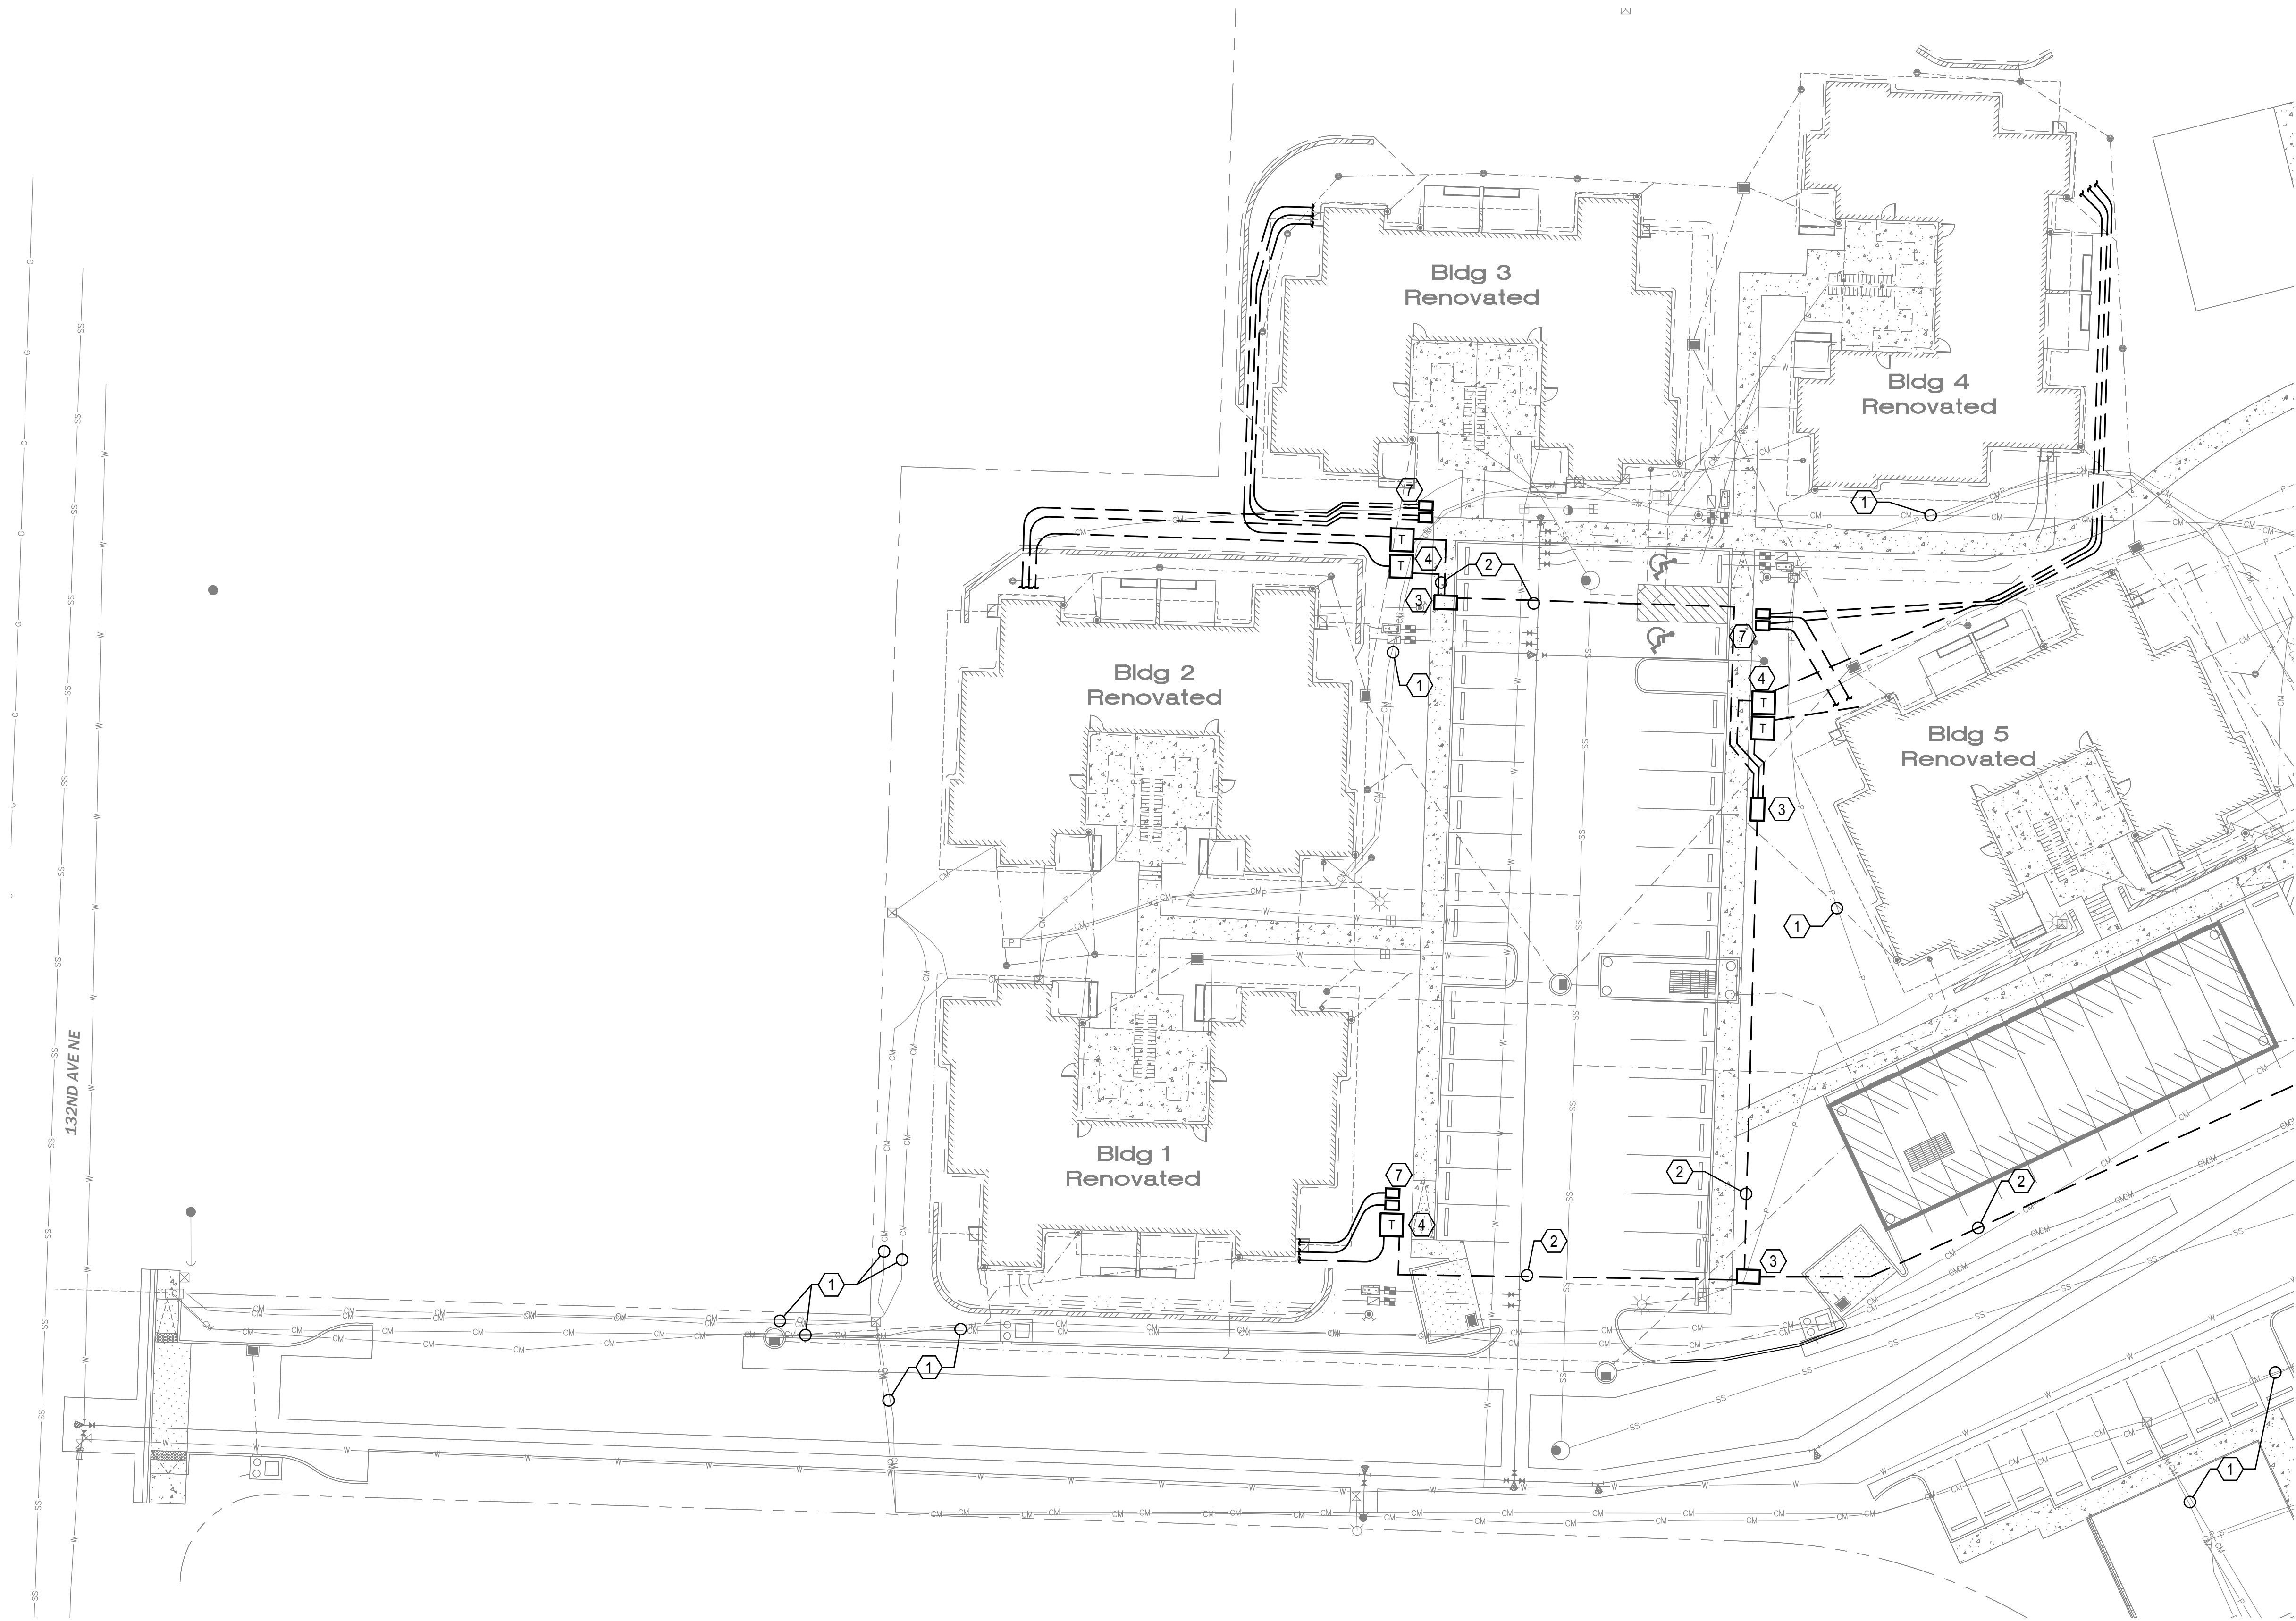

ELECTRICAL SITE PLAN - SECTION 1

SCALE: 1"=20'-0"

GENERAL NOTES:

- CONTRACTOR(S) TO PROVIDE AND EXECUTE LOCATES AND VERIFY ALL EXISTING UTILITY CONDITIONS PRIOR TO SITE ALTERATIONS.
- COORDINATE ALL LOCATIONS AND ROUTING OF NEW UTILITY ELEMENTS WITH CIVIL AND ALL UTILITY PROVIDERS PRIOR TO ANY SITE WORK AND ROUGH-IN.
- ALL TRENCHING AND BACKFILL NEEDED FOR ELECTRICAL SCOPE IS TO BE PROVIDED BY THE GENERAL CONTRACTOR.
- ALL UTILITY TRANSFORMERS ARE TO BE PLACED IN SITE LOCATIONS THAT PROVIDE A FLAT GRADED SURFACE WITH 10-FEET OF CLEARANCE TO ANY COMBUSTIBLE CONSTRUCTION ELEMENTS AND MEETING PSE REQUIREMENTS FOR WORKING AREA.
- CONDUIT ROUTING TO BUILDING FOR REFERENCE ONLY. SEE INDIVIDUAL BUILDING SITE PLANS FOR ADDITIONAL INFORMATION.

FLAG NOTES (X):

- ALL EXISTING POWER AND TELECOM UTILITIES ARE TO BE REPLACED WITH NEW INFRASTRUCTURE. EXISTING INFRASTRUCTURE TO BE DISCONNECTED AND ABANDONED IN PLACE WHERE POSSIBLE OR DEMOLISHED WHERE CONFLICTS EXIST WITH NEW SITE INFRASTRUCTURE. THE GENERAL AND ELECTRICAL CONTRACTORS ARE TO COORDINATE DIRECTLY WITH ALL UTILITY PROVIDERS TO ESTABLISH A SCHEDULE AND SEQUENCING OF SERVICE DISCONNECTS AND INSTALLATION OF NEW INFRASTRUCTURE THROUGHOUT SITE.
- NEW UNDERGROUND PRIMARY POWER INFRASTRUCTURE BY PUGET SOUND ENERGY (PSE). PRIMARY POWER TO BE RUN IN A JOINT UTILITY TRENCH WITH NEW TELECOM INFRASTRUCTURE. PSE TO PROVIDE ALL CONDUIT, J-BOXES, TRANSFORMERS, ETC. FOR PRIMARY POWER INFRASTRUCTURE. GENERAL AND ELECTRICAL CONTRACTOR TO PROVIDE TRENCHING PER PSE AND TELECOMMUNICATION PROVIDERS REQUIREMENTS.
- NEW IN-GRADE PRIMARY POWER JUNCTION BOX PROVIDED BY PSE.
- NEW PAD MOUNTED TRANSFORMER FOR INDIVIDUAL BUILDING SERVICE CONNECTION(S). PSE TO PROVIDE AND INSTALL TRANSFORMER AND MAKE ALL CONNECTIONS. SEE INDIVIDUAL BUILDING PLAN SETS FOR LOCATIONS AND ADDITIONAL INSTALLATION REQUIREMENTS.
- NOT USED.
- NOT USED.
- NEW RECESSED IN-GRADE JUNCTION BOX FOR TELECOM. SERVICE CONNECTION(S) TO THE INDIVIDUAL BUILDINGS. SEE INDIVIDUAL BUILDING PLAN SETS FOR LOCATIONS AND ADDITIONAL INSTALLATION REQUIREMENTS.
- EXISTING PSE TRANSFORMER TO REMAIN. COORDINATE NEW PRIMARY AND SECONDARY CONNECTIONS WITH PSE. SEE INDIVIDUAL BUILDING PLAN SETS FOR LOCATION AND ADDITIONAL INSTALLATION REQUIREMENTS.
- PROVIDE PRIMARY SERVICE FEEDERS FROM THE EXISTING PSE POWER POLE TO THE NEW J-BOX PER PSE REQUIREMENTS AND STANDARDS.

ALL INFORMATION SHOWN IN REGARDS TO THE EXISTING SYSTEMS AND INSTALLATION WAS TAKEN FROM AVAILABLE RESOURCES. THE CONTRACTORS SHALL VISIT THE SITE PRIOR TO SUBMISSION OF BIDS AND FIELD VERIFY ACTUAL CONDITIONS RELATED TO THE SCOPE OF WORK FOR THIS PROJECT AND SHALL INCLUDE ALL WORK REQUIRED TO FULFILL THE PROJECT SCOPE BASED ON THE ACTUAL EXISTING CONDITIONS IN THEIR BID. INFORM ARCHITECT AND ENGINEER OF CONFLICTS.



SIDER+BYERS
MECHANICAL + ELECTRICAL ENGINEERS

192 Nickerson, Suite #300
Seattle, Washington 98109
Phone: 206.285.2966

SMR Architects
117 S. Main St., Suite 400
Seattle, WA 98104

PH: 206.623.1104
FX: 206.623.5285



New Kirkland Heights LLLP
c/o: King County Housing Authority,
General Partner
13310 NE 133rd St.
Kirkland, WA 98034.
CONTRACT #: TC2300131

KIRKLAND HEIGHTS APARTMENTS

13324 NE 132nd St.,
Kirkland, WA 98034

SITE ELECTRICAL INFRASTRUCTURE BID SET



REVISIONS / NOTES		
NO	DATE	DESCRIPTION
1	5.19.23	BID ADDENDUM 2

DPD STAMP



TITLE

ELECTRICAL SITE PLAN - SECTION 1

PERMIT #	
DRAWN	RA, JF
CHECKED	GL
ISSUE DATE	04/14/2023
JOB NO.	22014

SHEET NO.:

E102

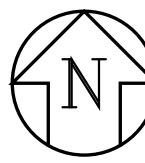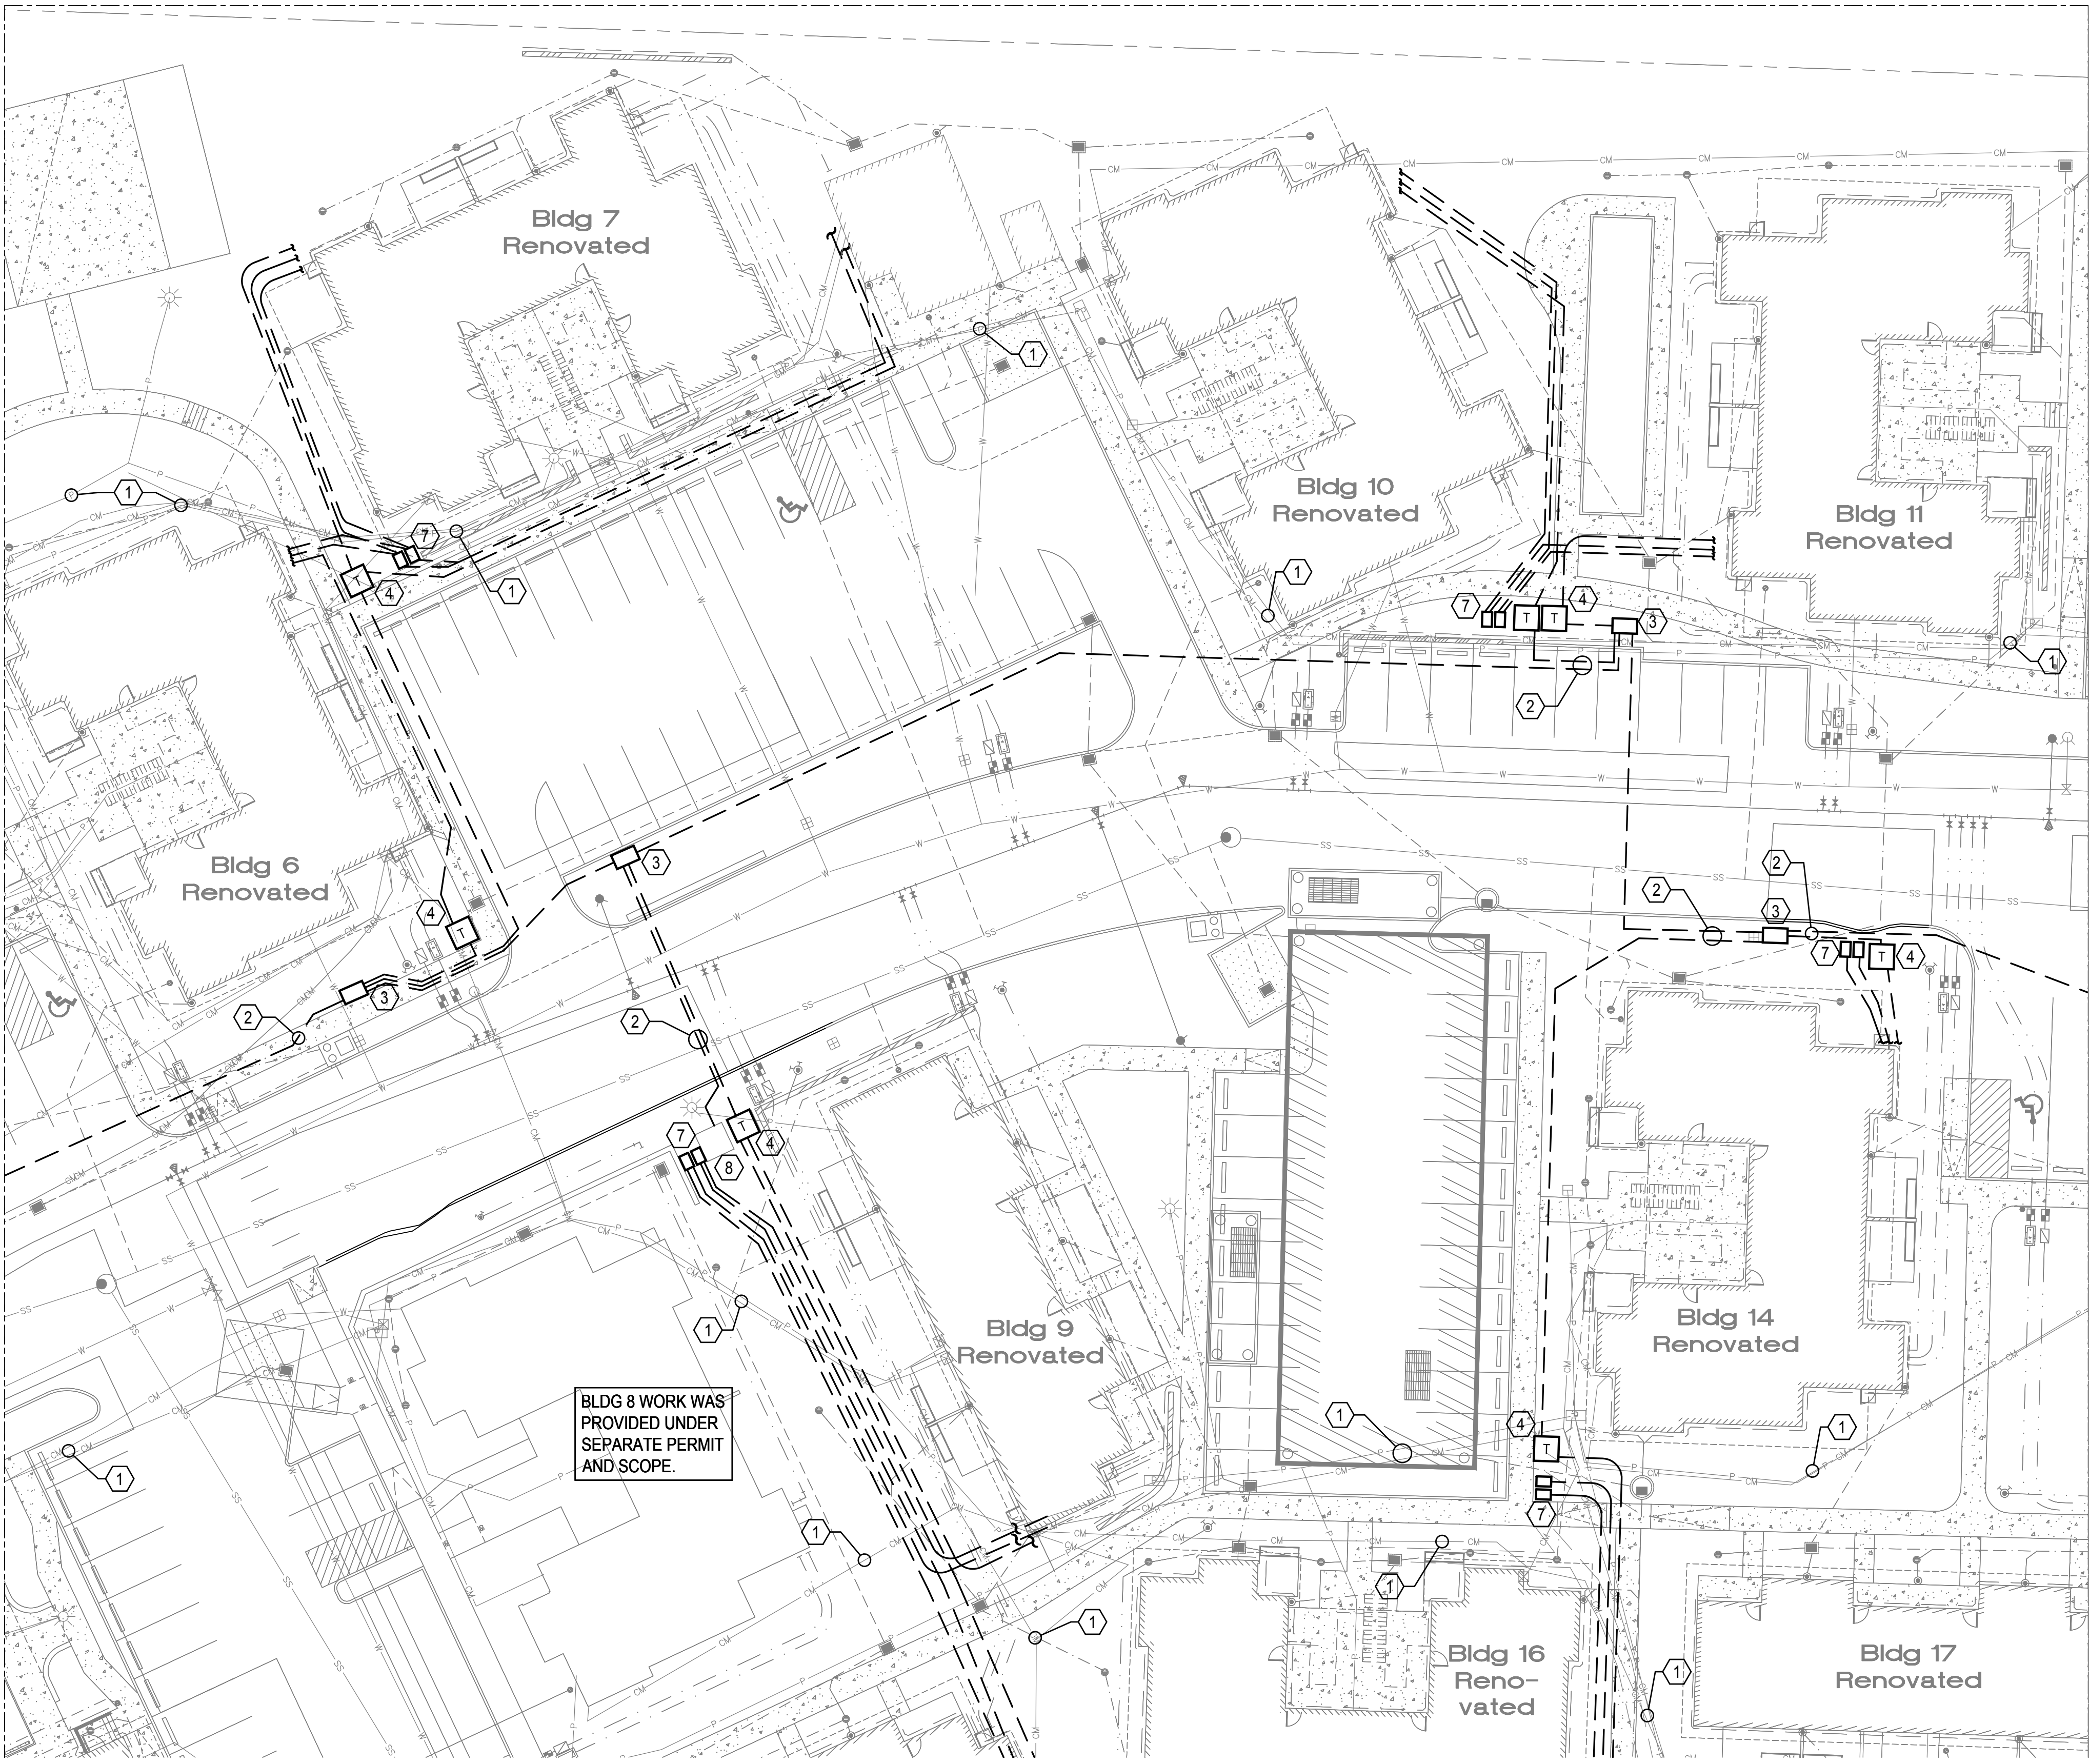

ELECTRICAL SITE PLAN - SECTION 2
SCALE: 1"=20'-0"

GENERAL NOTES:

- A. CONTRACTOR(S) TO PROVIDE AND EXECUTE LOCATES AND VERIFY ALL EXISTING UTILITY CONDITIONS PRIOR TO SITE ALTERATIONS.
- B. COORDINATE ALL LOCATIONS AND ROUTING OF NEW UTILITY ELEMENTS WITH CIVIL AND ALL UTILITY PROVIDERS PRIOR TO ANY SITE WORK AND ROUGH-IN.
- C. ALL TRENCHING AND BACKFILL NEEDED FOR ELECTRICAL SCOPE IS TO BE PROVIDED BY THE GENERAL CONTRACTOR.
- D. ALL UTILITY TRANSFORMERS ARE TO BE PLACED IN SITE LOCATIONS THAT PROVIDE A FLAT GRADED SURFACE WITH 10-FEET OF CLEARANCE TO ANY COMBUSTIBLE CONSTRUCTION ELEMENTS AND MEETING PSE REQUIREMENTS FOR WORKING AREA.
- E. CONDUIT ROUTING TO BUILDING FOR REFERENCE ONLY. SEE INDIVIDUAL BUILDING SITE PLANS FOR ADDITIONAL INFORMATION.

FLAG NOTES (X):

1. ALL EXISTING POWER AND TELECOM UTILITIES ARE TO BE REPLACED WITH NEW INFRASTRUCTURE. EXISTING INFRASTRUCTURE TO BE DISCONNECTED AND ABANDONED IN PLACE WHERE POSSIBLE OR DEMOLISHED WHERE CONFLICTS EXIST WITH NEW SITE INFRASTRUCTURE. THE GENERAL AND ELECTRICAL CONTRACTORS ARE TO COORDINATE DIRECTLY WITH ALL UTILITY PROVIDERS TO ESTABLISH A SCHEDULE AND SEQUENCING OF SERVICE DISCONNECTS AND INSTALLATION OF NEW INFRASTRUCTURE THROUGHOUT SITE.
2. NEW UNDERGROUND PRIMARY POWER INFRASTRUCTURE BY PUGET SOUND ENERGY (PSE). PRIMARY POWER TO BE RUN IN A JOINT UTILITY TRENCH WITH NEW TELECOM INFRASTRUCTURE. PSE TO PROVIDE ALL CONDUIT, J-BOXES, TRANSFORMERS, ETC. FOR PRIMARY POWER INFRASTRUCTURE. GENERAL AND ELECTRICAL CONTRACTOR TO PROVIDE TRENCHING PER PSE AND TELECOMMUNICATION PROVIDERS REQUIREMENTS.
3. NEW IN-GRADE PRIMARY POWER JUNCTION BOX PROVIDED BY PSE.
4. NEW PAD MOUNTED TRANSFORMER FOR INDIVIDUAL BUILDING SERVICE CONNECTION(S). PSE TO PROVIDE AND INSTALL TRANSFORMER AND MAKE ALL CONNECTIONS. SEE INDIVIDUAL BUILDING PLAN SETS FOR LOCATIONS AND ADDITIONAL INSTALLATION REQUIREMENTS.
5. NOT USED.
6. NOT USED.
7. NEW RECESSED IN-GRADE JUNCTION BOX FOR TELECOM. SERVICE CONNECTION(S) TO THE INDIVIDUAL BUILDINGS. SEE INDIVIDUAL BUILDING PLAN SETS FOR LOCATIONS AND ADDITIONAL INSTALLATION REQUIREMENTS.
8. EXISTING PSE TRANSFORMER TO REMAIN. COORDINATE NEW PRIMARY AND SECONDARY CONNECTIONS WITH PSE. SEE INDIVIDUAL BUILDING PLAN SETS FOR LOCATION AND ADDITIONAL INSTALLATION REQUIREMENTS.
9. PROVIDE PRIMARY SERVICE FEEDERS FROM THE EXISTING PSE POWER POLE TO THE NEW J-BOX PER PSE REQUIREMENTS AND STANDARDS.

ALL INFORMATION SHOWN IN REGARDS TO THE EXISTING SYSTEMS AND INSTALLATION WAS TAKEN FROM AVAILABLE RESOURCES. THE CONTRACTORS SHALL VISIT THE SITE PRIOR TO SUBMISSION OF BIDS AND FIELD VERIFY ACTUAL CONDITIONS RELATED TO THE SCOPE OF WORK FOR THIS PROJECT AND SHALL INCLUDE ALL WORK REQUIRED TO FULFILL THE PROJECT SCOPE BASED ON THE ACTUAL EXISTING CONDITIONS IN THEIR BID. INFORM ARCHITECT AND ENGINEER OF CONFLICTS.



SIDER+BYERS
MECHANICAL + ELECTRICAL ENGINEERS

192 Nickerson, Suite #300
Seattle, Washington 98109
Phone: 206.285.2966

SMR Architects
117 S. Main St., Suite 400
Seattle, WA 98104

PH: 206.623.1104
FX: 206.623.5285



New Kirkland Heights LLLP
c/o: King County Housing Authority,
General Partner
13310 NE 133rd St.
Kirkland, WA 98034.
CONTRACT #: TC2300131

**KIRKLAND
HEIGHTS
APARTMENTS**

13324 NE 132nd St.,
Kirkland, WA 98034

**SITE ELECTRICAL
INFRASTRUCTURE
BID SET**





REVISIONS / NOTES		
NO	DATE	DESCRIPTION
1	5.19.23	BID ADDENDUM 2

DPD STAMP

**ELECTRICAL
SITE PLAN -
SECTION 2**

PERMIT #	
DRAWN	RA, JF
CHECKED	GL
ISSUE DATE	04/14/2023
JOB NO.	22014
SHEET NO.:	

E103

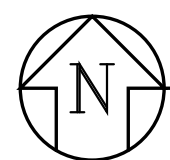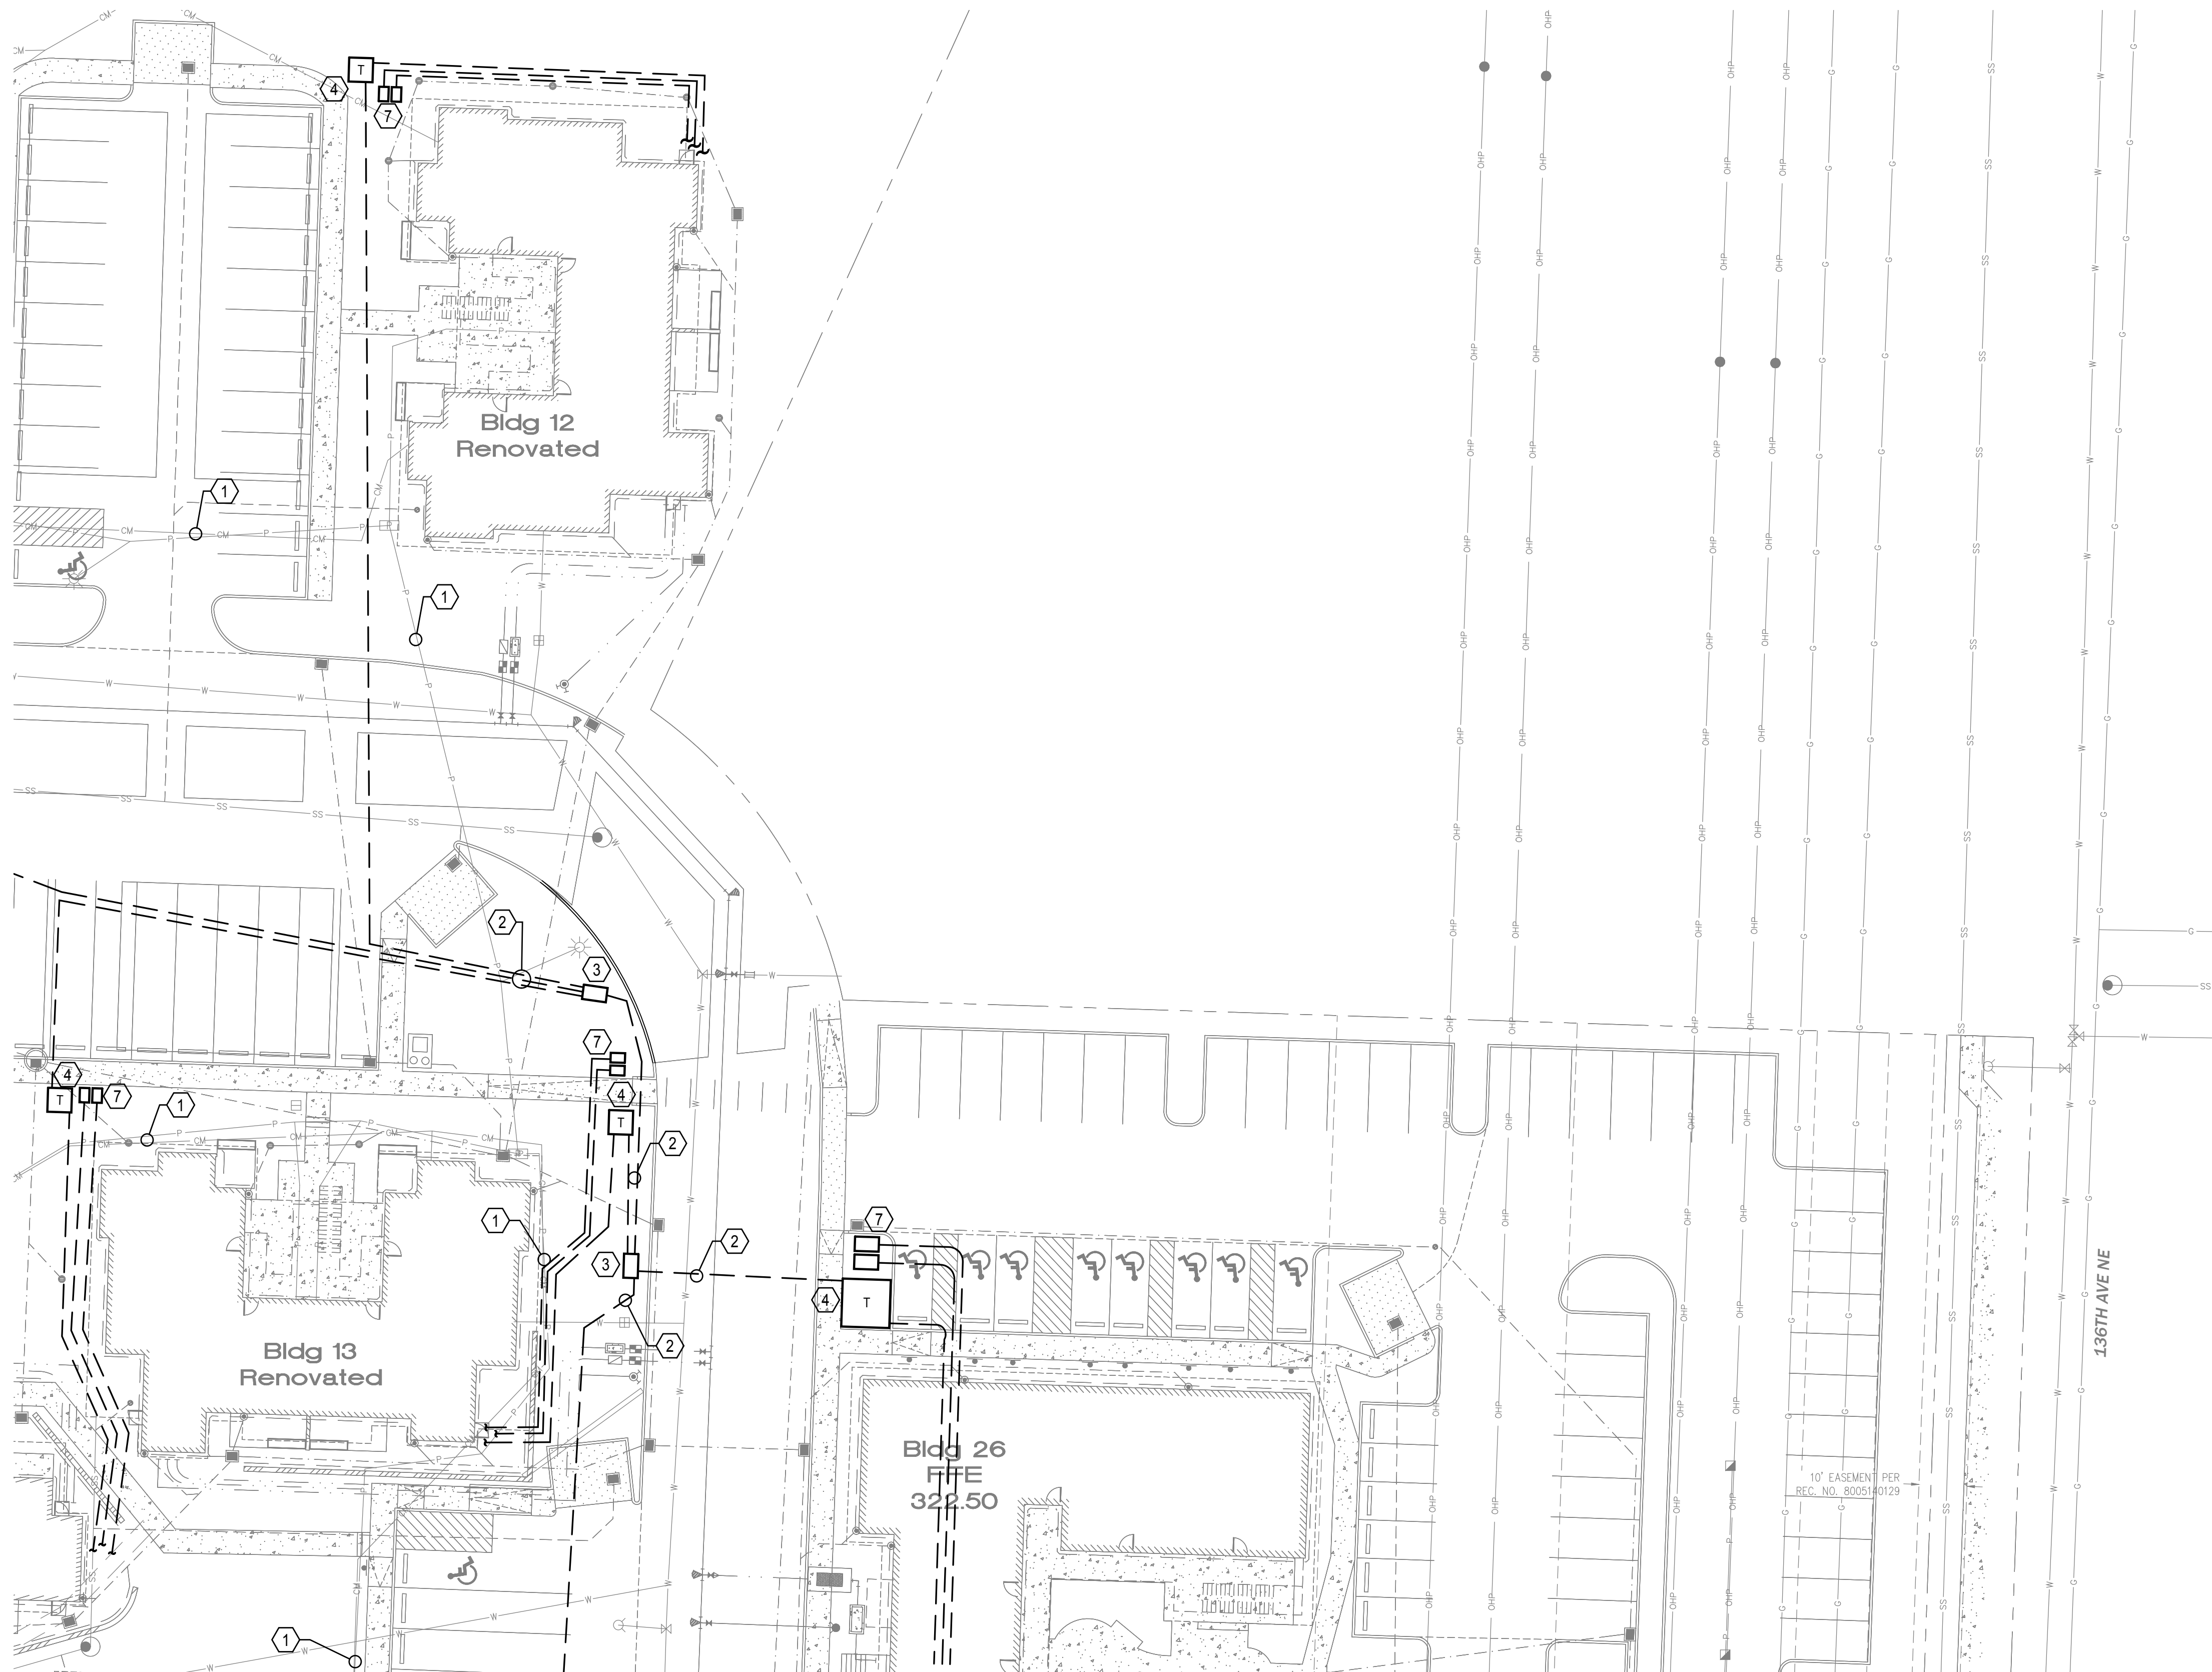

ELECTRICAL SITE PLAN - SECTION 3

SCALE: 1"=20'-0"

GENERAL NOTES:

- CONTRACTOR(S) TO PROVIDE AND EXECUTE LOCATES AND VERIFY ALL EXISTING UTILITY CONDITIONS PRIOR TO SITE ALTERATIONS.
- COORDINATE ALL LOCATIONS AND ROUTING OF NEW UTILITY ELEMENTS WITH CIVIL AND ALL UTILITY PROVIDERS PRIOR TO ANY SITE WORK AND ROUGH-IN.
- ALL TRENCHING AND BACKFILL NEEDED FOR ELECTRICAL SCOPE IS TO BE PROVIDED BY THE GENERAL CONTRACTOR.
- ALL UTILITY TRANSFORMERS ARE TO BE PLACED IN SITE LOCATIONS THAT PROVIDE A FLAT GRADED SURFACE WITH 10-FEET OF CLEARANCE TO ANY COMBUSTIBLE CONSTRUCTION ELEMENTS AND MEETING PSE REQUIREMENTS FOR WORKING AREA.
- CONDUIT ROUTING TO BUILDING FOR REFERENCE ONLY. SEE INDIVIDUAL BUILDING SITE PLANS FOR ADDITIONAL INFORMATION.

FLAG NOTES (X):

- ALL EXISTING POWER AND TELECOM UTILITIES ARE TO BE REPLACED WITH NEW INFRASTRUCTURE. EXISTING INFRASTRUCTURE TO BE DISCONNECTED AND ABANDONED IN PLACE WHERE POSSIBLE OR DEMOLISHED WHERE CONFLICTS EXIST WITH NEW SITE INFRASTRUCTURE. THE GENERAL AND ELECTRICAL CONTRACTORS ARE TO COORDINATE DIRECTLY WITH ALL UTILITY PROVIDERS TO ESTABLISH A SCHEDULE AND SEQUENCING OF SERVICE DISCONNECTS AND INSTALLATION OF NEW INFRASTRUCTURE THROUGHOUT SITE.
- NEW UNDERGROUND PRIMARY POWER INFRASTRUCTURE BY PUGET SOUND ENERGY (PSE). PRIMARY POWER TO BE RUN IN A JOINT UTILITY TRENCH WITH NEW TELECOM INFRASTRUCTURE. PSE TO PROVIDE ALL CONDUIT, J-BOXES, TRANSFORMERS, ETC. FOR PRIMARY POWER INFRASTRUCTURE. GENERAL AND ELECTRICAL CONTRACTOR TO PROVIDE TRENCHING PER PSE AND TELECOMMUNICATION PROVIDERS REQUIREMENTS.
- NEW IN-GRADE PRIMARY POWER JUNCTION BOX PROVIDED BY PSE.
- NEW PAD MOUNTED TRANSFORMER FOR INDIVIDUAL BUILDING SERVICE CONNECTION(S). PSE TO PROVIDE AND INSTALL TRANSFORMER AND MAKE ALL CONNECTIONS. SEE INDIVIDUAL BUILDING PLAN SETS FOR LOCATIONS AND ADDITIONAL INSTALLATION REQUIREMENTS.
- NOT USED.
- NOT USED.
- NEW RECESSED IN-GRADE JUNCTION BOX FOR TELECOM. SERVICE CONNECTION(S) TO THE INDIVIDUAL BUILDINGS. SEE INDIVIDUAL BUILDING PLAN SETS FOR LOCATIONS AND ADDITIONAL INSTALLATION REQUIREMENTS.
- EXISTING PSE TRANSFORMER TO REMAIN. COORDINATE NEW PRIMARY AND SECONDARY CONNECTIONS WITH PSE. SEE INDIVIDUAL BUILDING PLAN SETS FOR LOCATION AND ADDITIONAL INSTALLATION REQUIREMENTS.
- PROVIDE PRIMARY SERVICE FEEDERS FROM THE EXISTING PSE POWER POLE TO THE NEW J-BOX PER PSE REQUIREMENTS AND STANDARDS.

ALL INFORMATION SHOWN IN REGARDS TO THE EXISTING SYSTEMS AND INSTALLATION WAS TAKEN FROM AVAILABLE RESOURCES. THE CONTRACTORS SHALL VISIT THE SITE PRIOR TO SUBMISSION OF BIDS AND FIELD VERIFY ACTUAL CONDITIONS RELATED TO THE SCOPE OF WORK FOR THIS PROJECT AND SHALL INCLUDE ALL WORK REQUIRED TO FULFILL THE PROJECT SCOPE BASED ON THE ACTUAL EXISTING CONDITIONS IN THEIR BID. INFORM ARCHITECT AND ENGINEER OF CONFLICTS.



SIDER+BYERS
MECHANICAL + ELECTRICAL ENGINEERS

192 Nickerson, Suite #300
Seattle, Washington 98109
Phone: 206.285.2966

SMR Architects
117 S. Main St., Suite 400
Seattle, WA 98104

PH: 206.623.1104
FX: 206.623.5285



New Kirkland Heights LLLP
c/o: King County Housing Authority,
General Partner
13310 NE 133rd St.
Kirkland, WA 98034.
CONTRACT #: TC2300131

KIRKLAND HEIGHTS APARTMENTS

13324 NE 132nd St.,
Kirkland, WA 98034

SITE ELECTRICAL INFRASTRUCTURE BID SET



REVISIONS / NOTES		
NO	DATE	DESCRIPTION
1	5.19.23	BID ADDENDUM 2

DPD STAMP

TITLE

ELECTRICAL SITE PLAN - SECTION 3

PERMIT #	
DRAWN	RA, JF
CHECKED	GL
ISSUE DATE	04/14/2023
JOB NO.	22014
SHEET NO.:	

E104



SIDER+BYERS
MECHANICAL • ELECTRICAL ENGINEERS

192 Nickerson, Suite #300
Seattle, Washington 98109
Phone: 206.285.2966

SMR Architects
117 S. Main St., Suite 400
Seattle, WA 98104

PH: 206.623.1104
FX: 206.623.5285



New Kirkland Heights LLLP
c/o: King County Housing Authority,
General Partner
13310 NE 133rd St.
Kirkland, WA 98034
CONTRACT #: TC2300131

KIRKLAND HEIGHTS APARTMENTS

13324 NE 132nd St.,
Kirkland, WA 98034

SITE ELECTRICAL INFRASTRUCTURE BID SET




REVISIONS / NOTES		
NO	DATE	DESCRIPTION
1	5.19.23	BID ADDENDUM 2

DPD STAMP

ELECTRICAL SITE PLAN - SECTION 4

PERMIT #	
DRAWN	RA, JF
CHECKED	GL
ISSUE DATE	04/14/2023
JOB NO.	22014
SHEET NO.:	

E105

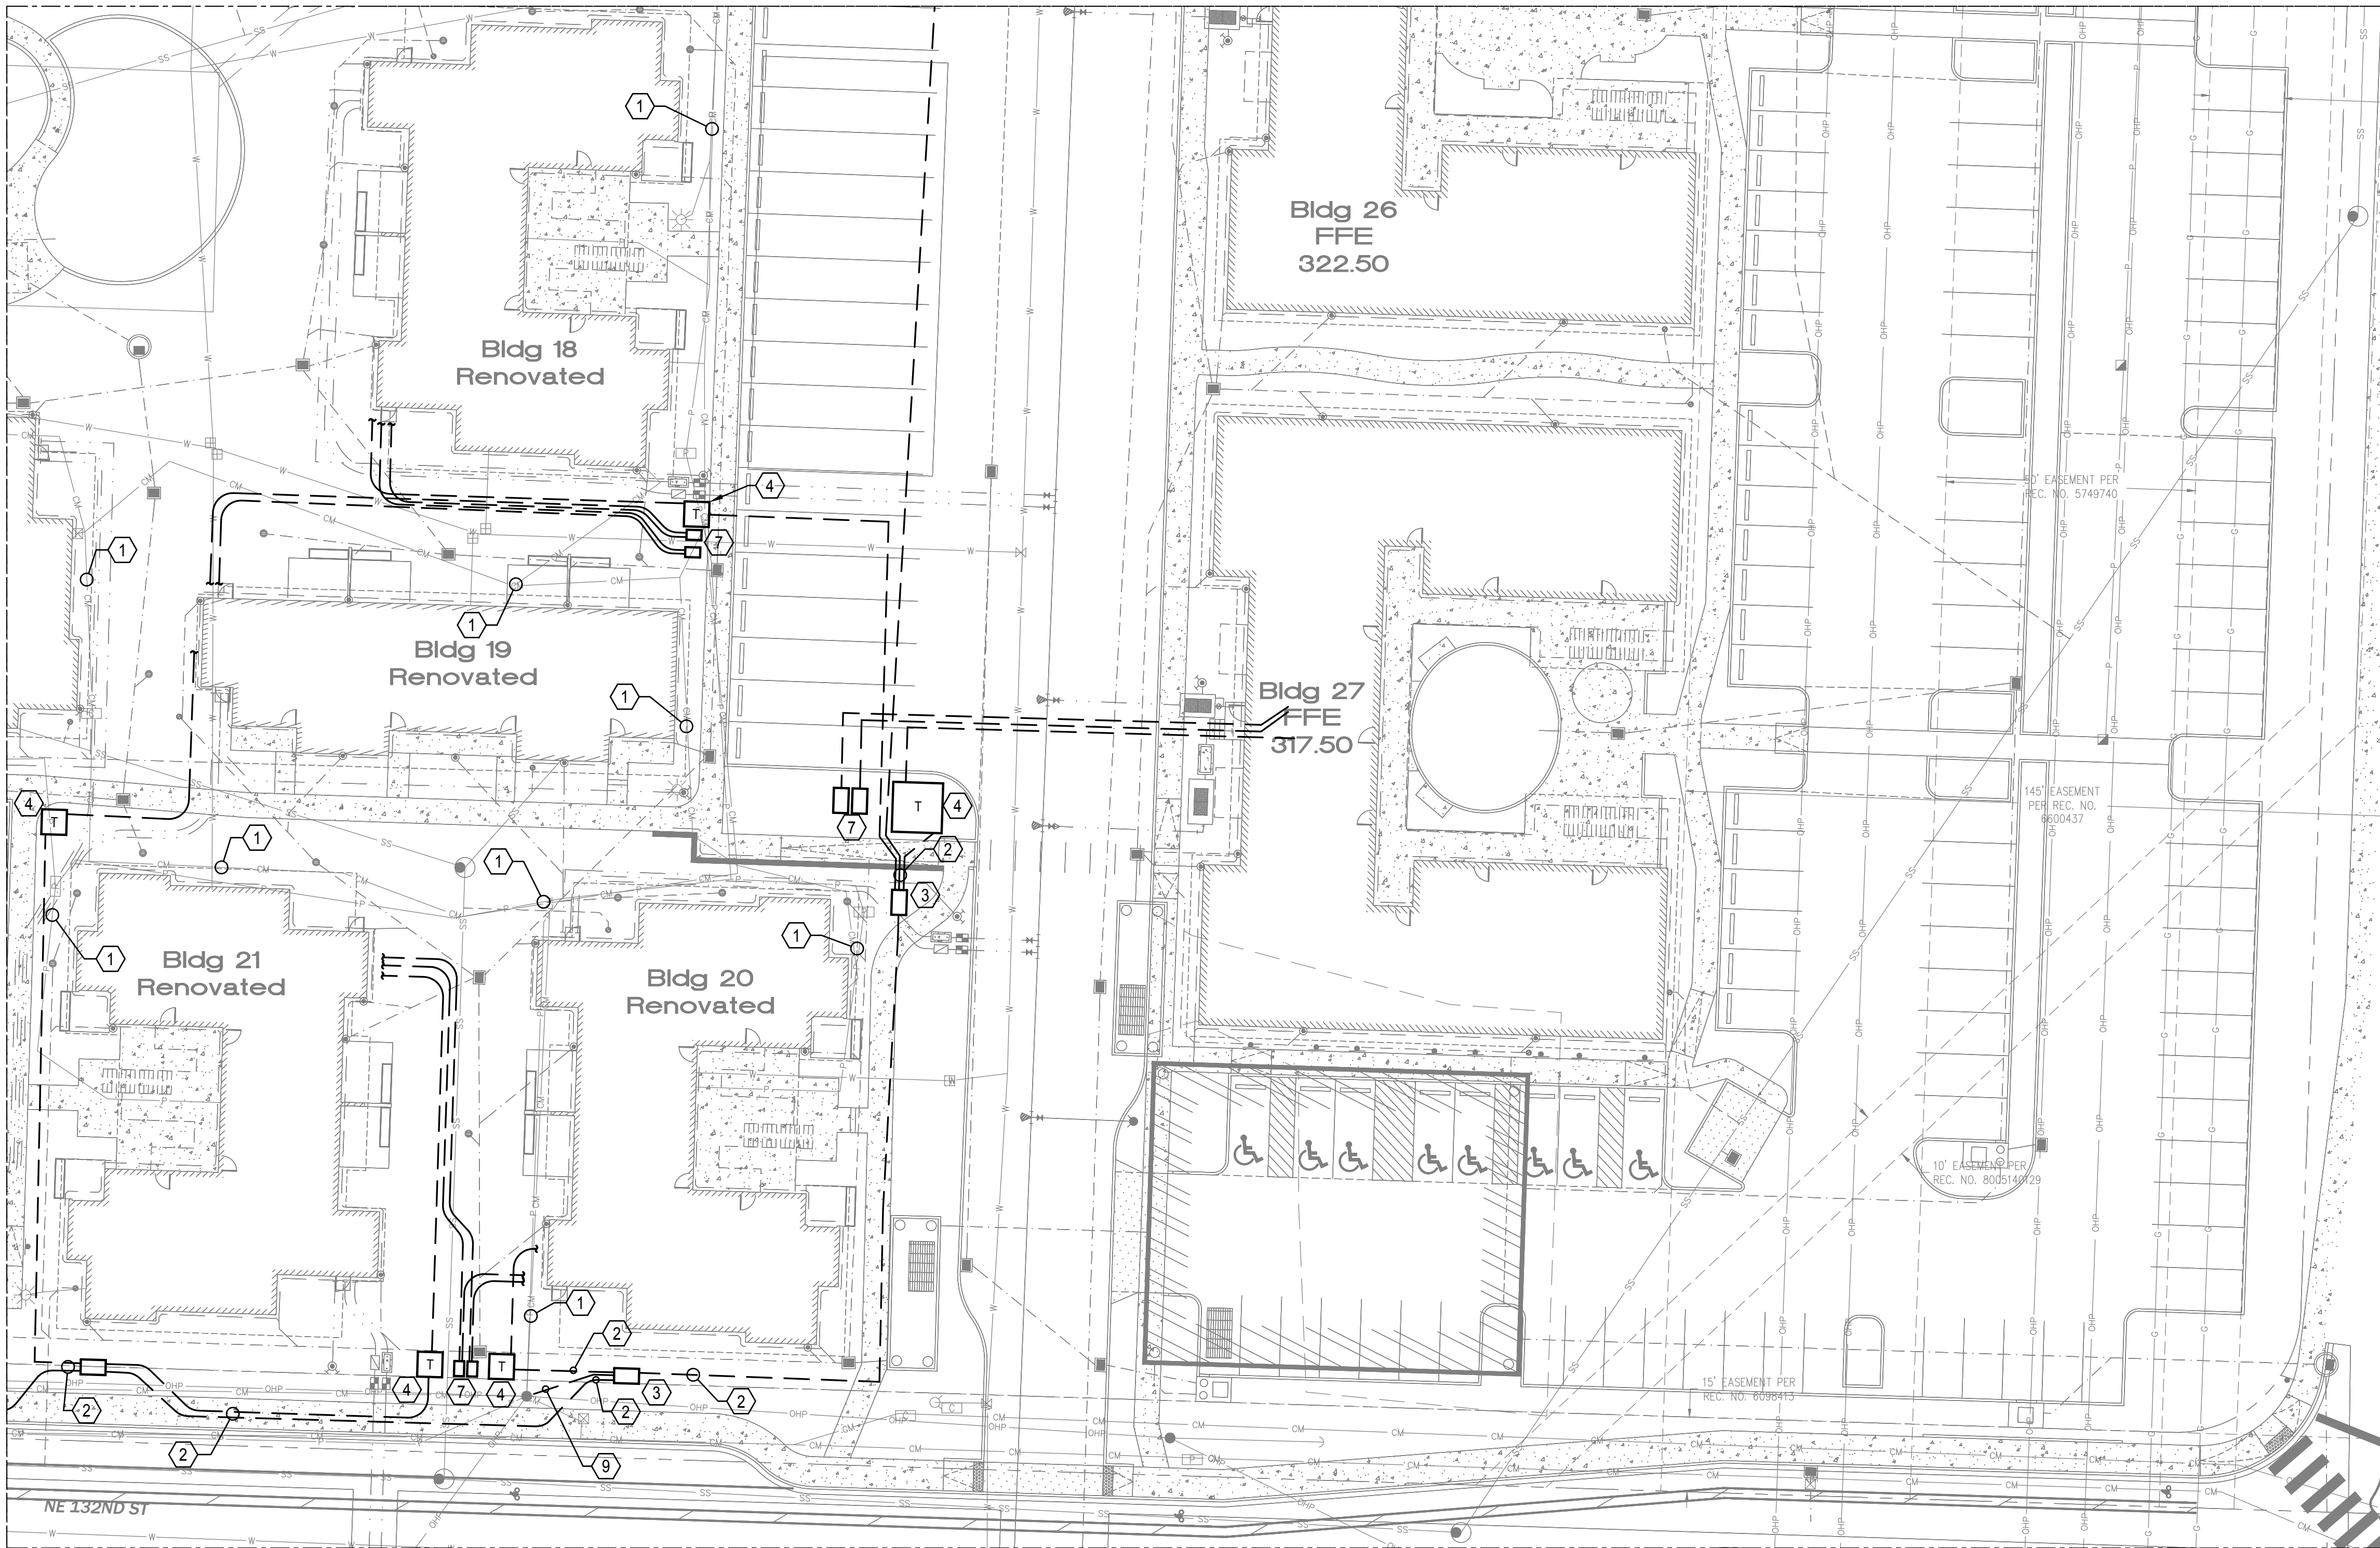

ELECTRICAL SITE PLAN - SECTION 4

SCALE: 1"=20'-0"


GENERAL NOTES:

- CONTRACTOR(S) TO PROVIDE AND EXECUTE LOCATES AND VERIFY ALL EXISTING UTILITY CONDITIONS PRIOR TO SITE ALTERATIONS.
- COORDINATE ALL LOCATIONS AND ROUTING OF NEW UTILITY ELEMENTS WITH CIVIL AND ALL UTILITY PROVIDERS PRIOR TO ANY SITE WORK AND ROUGH-IN.
- ALL TRENCHING AND BACKFILL NEEDED FOR ELECTRICAL SCOPE IS TO BE PROVIDED BY THE GENERAL CONTRACTOR.
- ALL UTILITY TRANSFORMERS ARE TO BE PLACED IN SITE LOCATIONS THAT PROVIDE A FLAT GRADED SURFACE WITH 10-FEET OF CLEARANCE TO ANY COMBUSTIBLE CONSTRUCTION ELEMENTS AND MEETING PSE REQUIREMENTS FOR WORKING AREA.
- CONDUIT ROUTING TO BUILDING FOR REFERENCE ONLY. SEE INDIVIDUAL BUILDING SITE PLANS FOR ADDITIONAL INFORMATION.

FLAG NOTES (X):

- ALL EXISTING POWER AND TELECOM UTILITIES ARE TO BE REPLACED WITH NEW INFRASTRUCTURE. EXISTING INFRASTRUCTURE TO BE DISCONNECTED AND ABANDONED IN PLACE WHERE POSSIBLE OR DEMOLISHED WHERE CONFLICTS EXIST WITH NEW SITE INFRASTRUCTURE. THE GENERAL AND ELECTRICAL CONTRACTORS ARE TO COORDINATE DIRECTLY WITH ALL UTILITY PROVIDERS TO ESTABLISH A SCHEDULE AND SEQUENCING OF SERVICE DISCONNECTS AND INSTALLATION OF NEW INFRASTRUCTURE THROUGHOUT SITE.
- NEW UNDERGROUND PRIMARY POWER INFRASTRUCTURE BY PUGET SOUND ENERGY (PSE). PRIMARY POWER TO BE RUN IN A JOINT UTILITY TRENCH WITH NEW TELECOM INFRASTRUCTURE. PSE TO PROVIDE ALL CONDUIT, J-BOXES, TRANSFORMERS, ETC. FOR PRIMARY POWER INFRASTRUCTURE. GENERAL AND ELECTRICAL CONTRACTOR TO PROVIDE TRENCHING PER PSE AND TELECOMMUNICATION PROVIDERS REQUIREMENTS.
- NEW IN-GRADE PRIMARY POWER JUNCTION BOX PROVIDED BY PSE.
- NEW PAD MOUNTED TRANSFORMER FOR INDIVIDUAL BUILDING SERVICE CONNECTION(S). PSE TO PROVIDE AND INSTALL TRANSFORMER AND MAKE ALL CONNECTIONS. SEE INDIVIDUAL BUILDING PLAN SETS FOR LOCATIONS AND ADDITIONAL INSTALLATION REQUIREMENTS.
- NOT USED.
- NOT USED.
- NEW RECESSED IN-GRADE JUNCTION BOX FOR TELECOM. SERVICE CONNECTION(S) TO THE INDIVIDUAL BUILDINGS. SEE INDIVIDUAL BUILDING PLAN SETS FOR LOCATIONS AND ADDITIONAL INSTALLATION REQUIREMENTS.
- EXISTING PSE TRANSFORMER TO REMAIN. COORDINATE NEW PRIMARY AND SECONDARY CONNECTIONS WITH PSE. SEE INDIVIDUAL BUILDING PLAN SETS FOR LOCATION AND ADDITIONAL INSTALLATION REQUIREMENTS.
- PROVIDE PRIMARY SERVICE FEEDERS FROM THE EXISTING PSE POWER POLE TO THE NEW J-BOX PER PSE REQUIREMENTS AND STANDARDS.

ALL INFORMATION SHOWN IN REGARDS TO THE EXISTING SYSTEMS AND INSTALLATION WAS TAKEN FROM AVAILABLE RESOURCES. THE CONTRACTORS SHALL VISIT THE SITE PRIOR TO SUBMISSION OF BIDS AND FIELD VERIFY ACTUAL CONDITIONS RELATED TO THE SCOPE OF WORK FOR THIS PROJECT AND SHALL INCLUDE ALL WORK REQUIRED TO FULFILL THE PROJECT SCOPE BASED ON THE ACTUAL EXISTING CONDITIONS IN THEIR BID. INFORM ARCHITECT AND ENGINEER OF CONFLICTS.

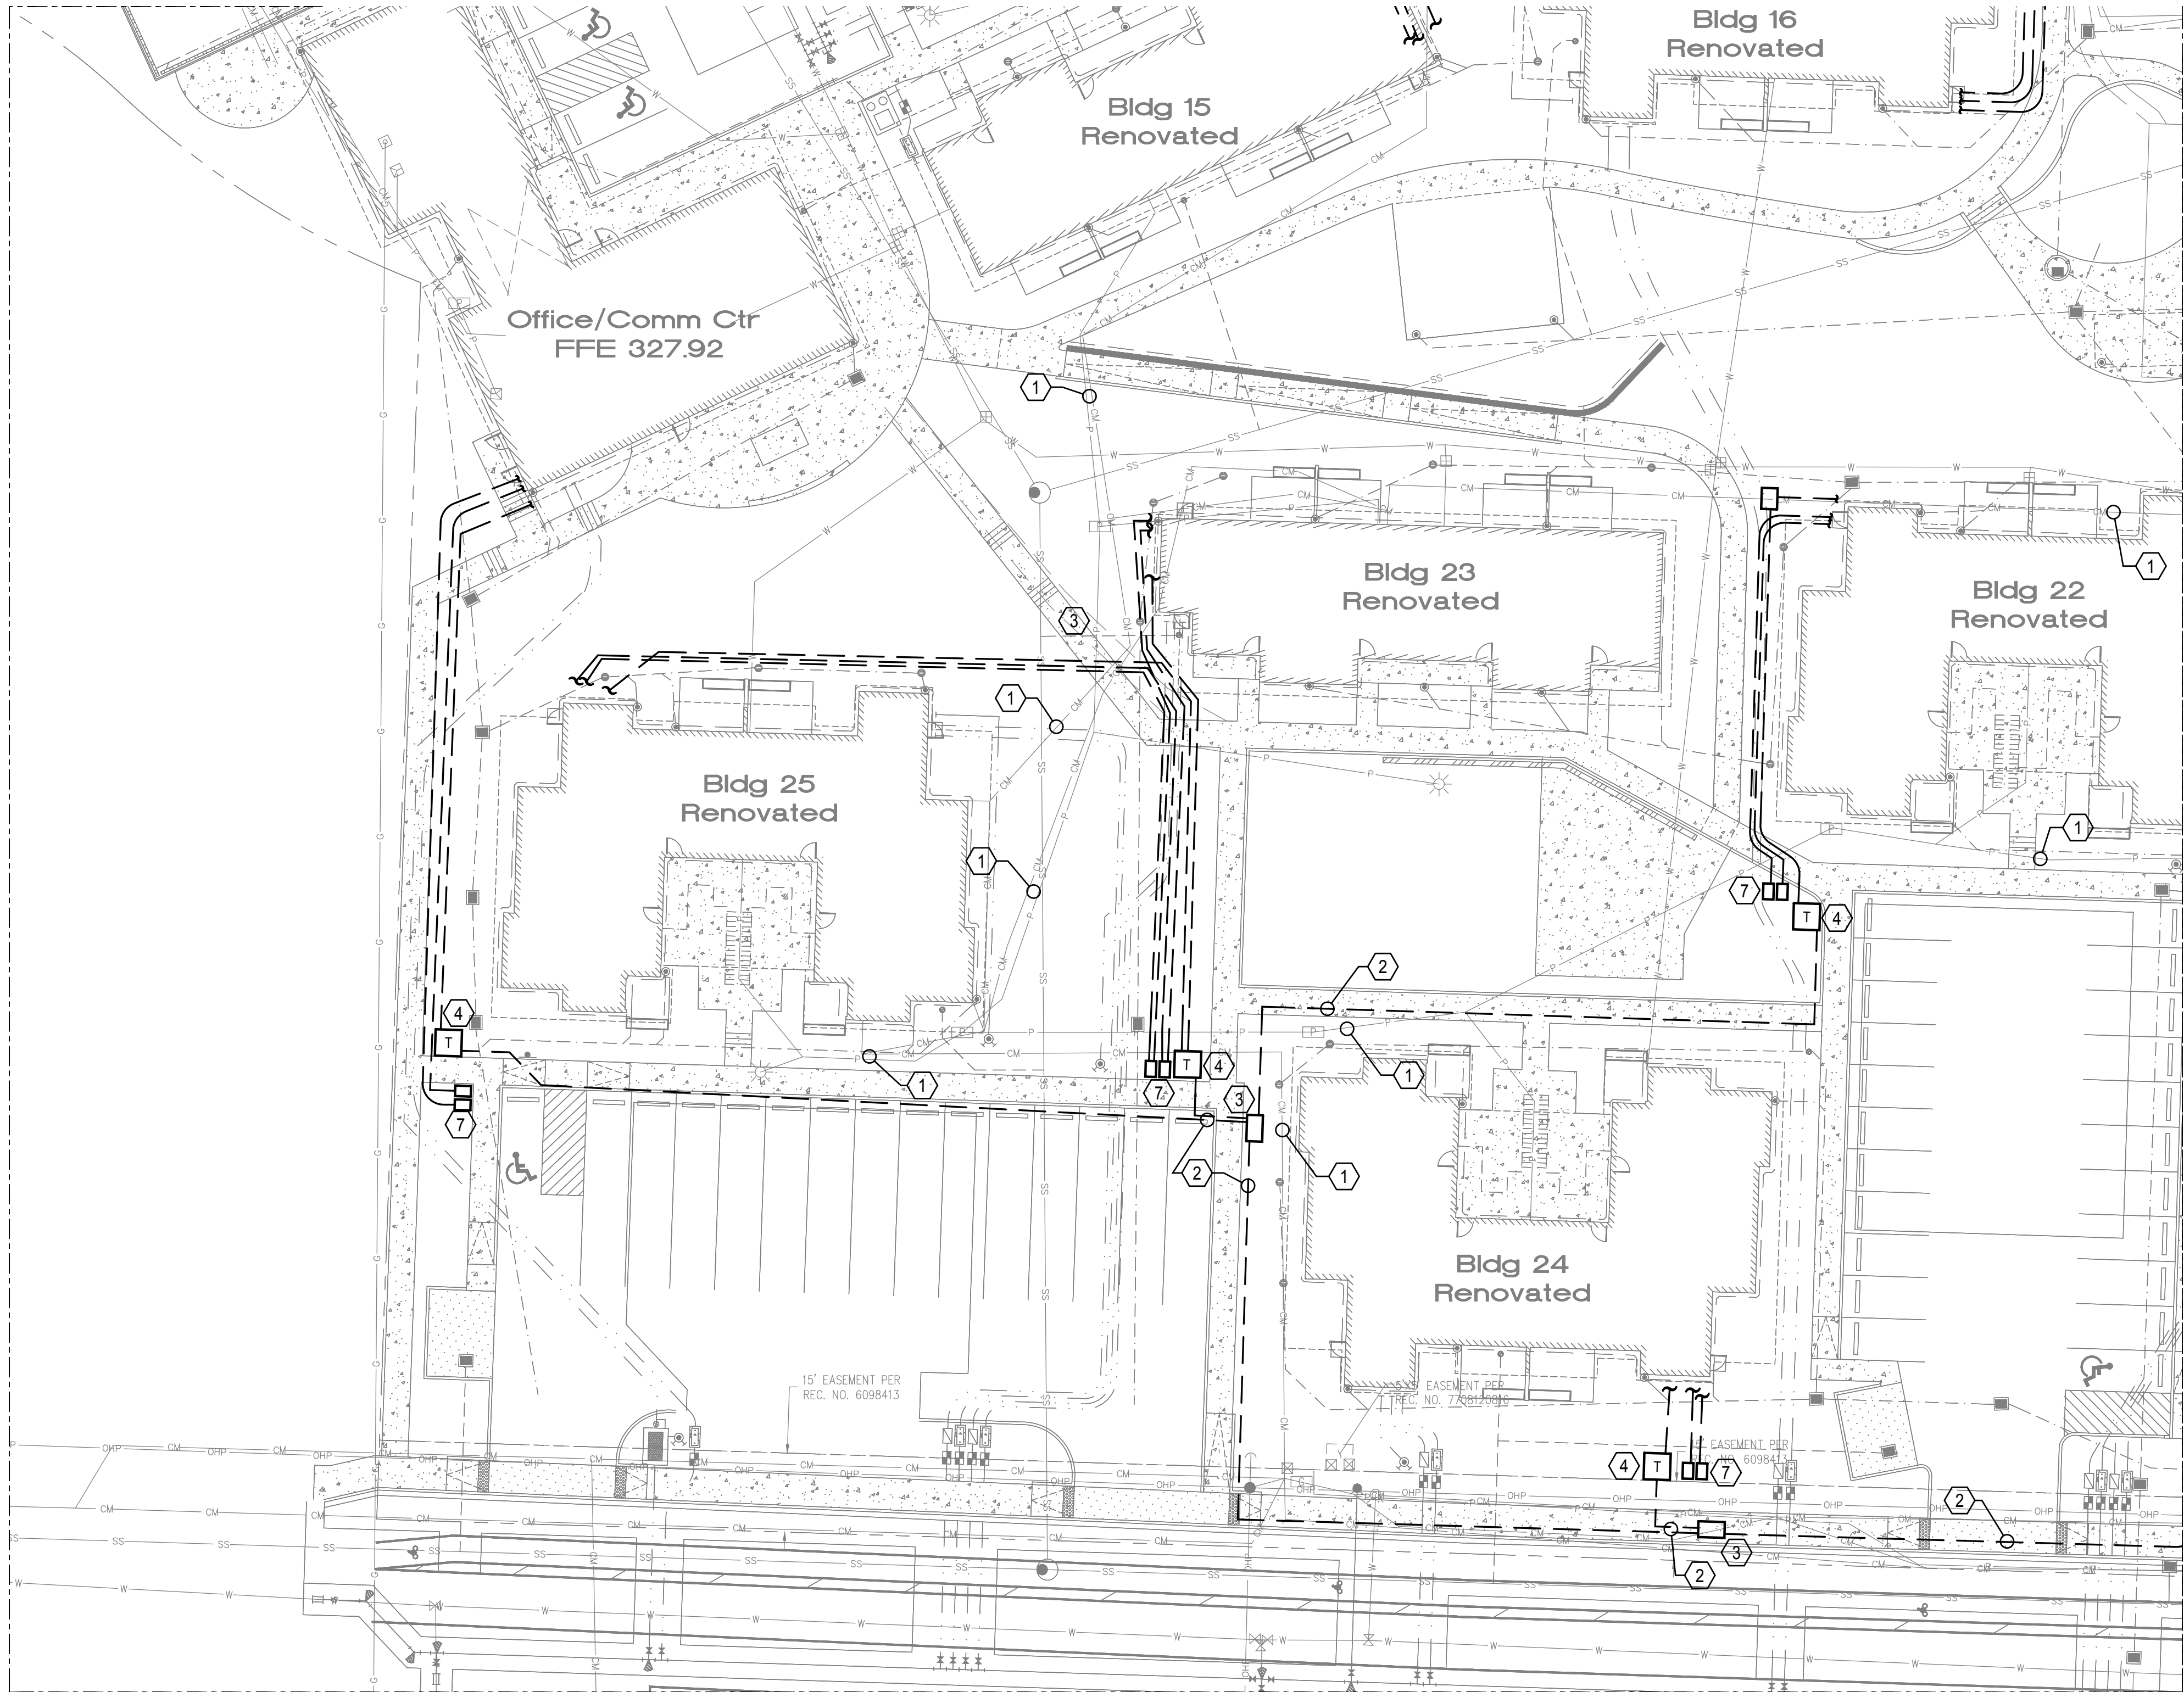

ELECTRICAL SITE PLAN - SECTION 5

SCALE: 1"=20'-0"


GENERAL NOTES:

- A. CONTRACTOR(S) TO PROVIDE AND EXECUTE LOCATES AND VERIFY ALL EXISTING UTILITY CONDITIONS PRIOR TO SITE ALTERATIONS.
- B. COORDINATE ALL LOCATIONS AND ROUTING OF NEW UTILITY ELEMENTS WITH CIVIL AND ALL UTILITY PROVIDERS PRIOR TO ANY SITE WORK AND ROUGH-IN.
- C. ALL TRENCHING AND BACKFILL NEEDED FOR ELECTRICAL SCOPE IS TO BE PROVIDED BY THE GENERAL CONTRACTOR.
- D. ALL UTILITY TRANSFORMERS ARE TO BE PLACED IN SITE LOCATIONS THAT PROVIDE A FLAT GRADED SURFACE WITH 10-FEET OF CLEARANCE TO ANY COMBUSTIBLE CONSTRUCTION ELEMENTS AND MEETING PSE REQUIREMENTS FOR WORKING AREA.
- E. CONDUIT ROUTING TO BUILDING FOR REFERENCE ONLY. SEE INDIVIDUAL BUILDING SITE PLANS FOR ADDITIONAL INFORMATION.

FLAG NOTES (X):

1. ALL EXISTING POWER AND TELECOM UTILITIES ARE TO BE REPLACED WITH NEW INFRASTRUCTURE. EXISTING INFRASTRUCTURE TO BE DISCONNECTED AND ABANDONED IN PLACE WHERE POSSIBLE OR DEMOLISHED WHERE CONFLICTS EXIST WITH NEW SITE INFRASTRUCTURE. THE GENERAL AND ELECTRICAL CONTRACTORS ARE TO COORDINATE DIRECTLY WITH ALL UTILITY PROVIDERS TO ESTABLISH A SCHEDULE AND SEQUENCING OF SERVICE DISCONNECTS AND INSTALLATION OF NEW INFRASTRUCTURE THROUGHOUT SITE.
2. NEW UNDERGROUND PRIMARY POWER INFRASTRUCTURE BY PUGET SOUND ENERGY (PSE). PRIMARY POWER TO BE RUN IN A JOINT UTILITY TRENCH WITH NEW TELECOM INFRASTRUCTURE. PSE TO PROVIDE ALL CONDUIT, J-BOXES, TRANSFORMERS, ETC. FOR PRIMARY POWER INFRASTRUCTURE. GENERAL AND ELECTRICAL CONTRACTOR TO PROVIDE TRENCHING PER PSE AND TELECOMMUNICATION PROVIDERS REQUIREMENTS.
3. NEW IN-GRADE PRIMARY POWER JUNCTION BOX PROVIDED BY PSE.
4. NEW PAD MOUNTED TRANSFORMER FOR INDIVIDUAL BUILDING SERVICE CONNECTION(S). PSE TO PROVIDE AND INSTALL TRANSFORMER AND MAKE ALL CONNECTIONS. SEE INDIVIDUAL BUILDING PLAN SETS FOR LOCATIONS AND ADDITIONAL INSTALLATION REQUIREMENTS.
5. NOT USED.
6. NOT USED.
7. NEW RECESSED IN-GRADE JUNCTION BOX FOR TELECOM. SERVICE CONNECTION(S) TO THE INDIVIDUAL BUILDINGS. SEE INDIVIDUAL BUILDING PLAN SETS FOR LOCATIONS AND ADDITIONAL INSTALLATION REQUIREMENTS.
8. EXISTING PSE TRANSFORMER TO REMAIN. COORDINATE NEW PRIMARY AND SECONDARY CONNECTIONS WITH PSE. SEE INDIVIDUAL BUILDING PLAN SETS FOR LOCATION AND ADDITIONAL INSTALLATION REQUIREMENTS.
9. PROVIDE PRIMARY SERVICE FEEDERS FROM THE EXISTING PSE POWER POLE TO THE NEW J-BOX PER PSE REQUIREMENTS AND STANDARDS.

ALL INFORMATION SHOWN IN REGARDS TO THE EXISTING SYSTEMS AND INSTALLATION WAS TAKEN FROM AVAILABLE RESOURCES. THE CONTRACTORS SHALL VISIT THE SITE PRIOR TO SUBMISSION OF BIDS AND FIELD VERIFY ACTUAL CONDITIONS RELATED TO THE SCOPE OF WORK FOR THIS PROJECT AND SHALL INCLUDE ALL WORK REQUIRED TO FULFILL THE PROJECT SCOPE BASED ON THE ACTUAL EXISTING CONDITIONS IN THEIR BID. INFORM ARCHITECT AND ENGINEER OF CONFLICTS.

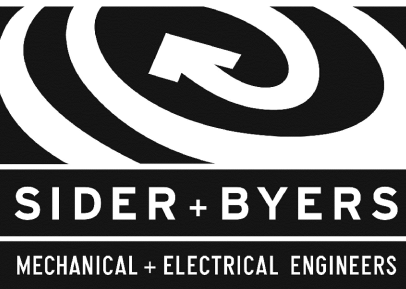

192 Nickerson, Suite #300
Seattle, Washington 98109
Phone: 206.285.2966

SMR Architects
117 S. Main St., Suite 400
Seattle, WA 98104

PH: 206.623.1104
FX: 206.623.5285



New Kirkland Heights LLLP
c/o: King County Housing Authority,
General Partner
13310 NE 133rd St.
Kirkland, WA 98034.
CONTRACT #: TC2300131

**KIRKLAND
HEIGHTS
APARTMENTS**

13324 NE 132nd St.,
Kirkland, WA 98034

**SITE ELECTRICAL
INFRASTRUCTURE
BID SET**



REVISIONS / NOTES		
NO	DATE	DESCRIPTION
1	5.19.23	BID ADDENDUM 2

DPD STAMP

**ELECTRICAL
SITE PLAN -
SECTION 5**

PERMIT #	
DRAWN	RA, JF
CHECKED	GL
ISSUE DATE	04/14/2023
JOB NO.	22014
SHEET NO.:	

E106

**KIRKLAND
HEIGHTS
APARTMENTS**

13324 NE 132nd St.,
Kirkland, WA 98034

**SITE ELECTRICAL
INFRASTRUCTURE
BID SET**




REVISIONS / NOTES		
NO	DATE	DESCRIPTION
1	5.19.23	BID ADDENDUM 2

DPD STAMP

TITLE
**SITE LIGHTING
PLAN -
OVERALL**

PERMIT #	RA, JF
CHECKED	GL
ISSUE DATE	04/14/2023
JOB NO.	22014
SHEET NO.:	


E110

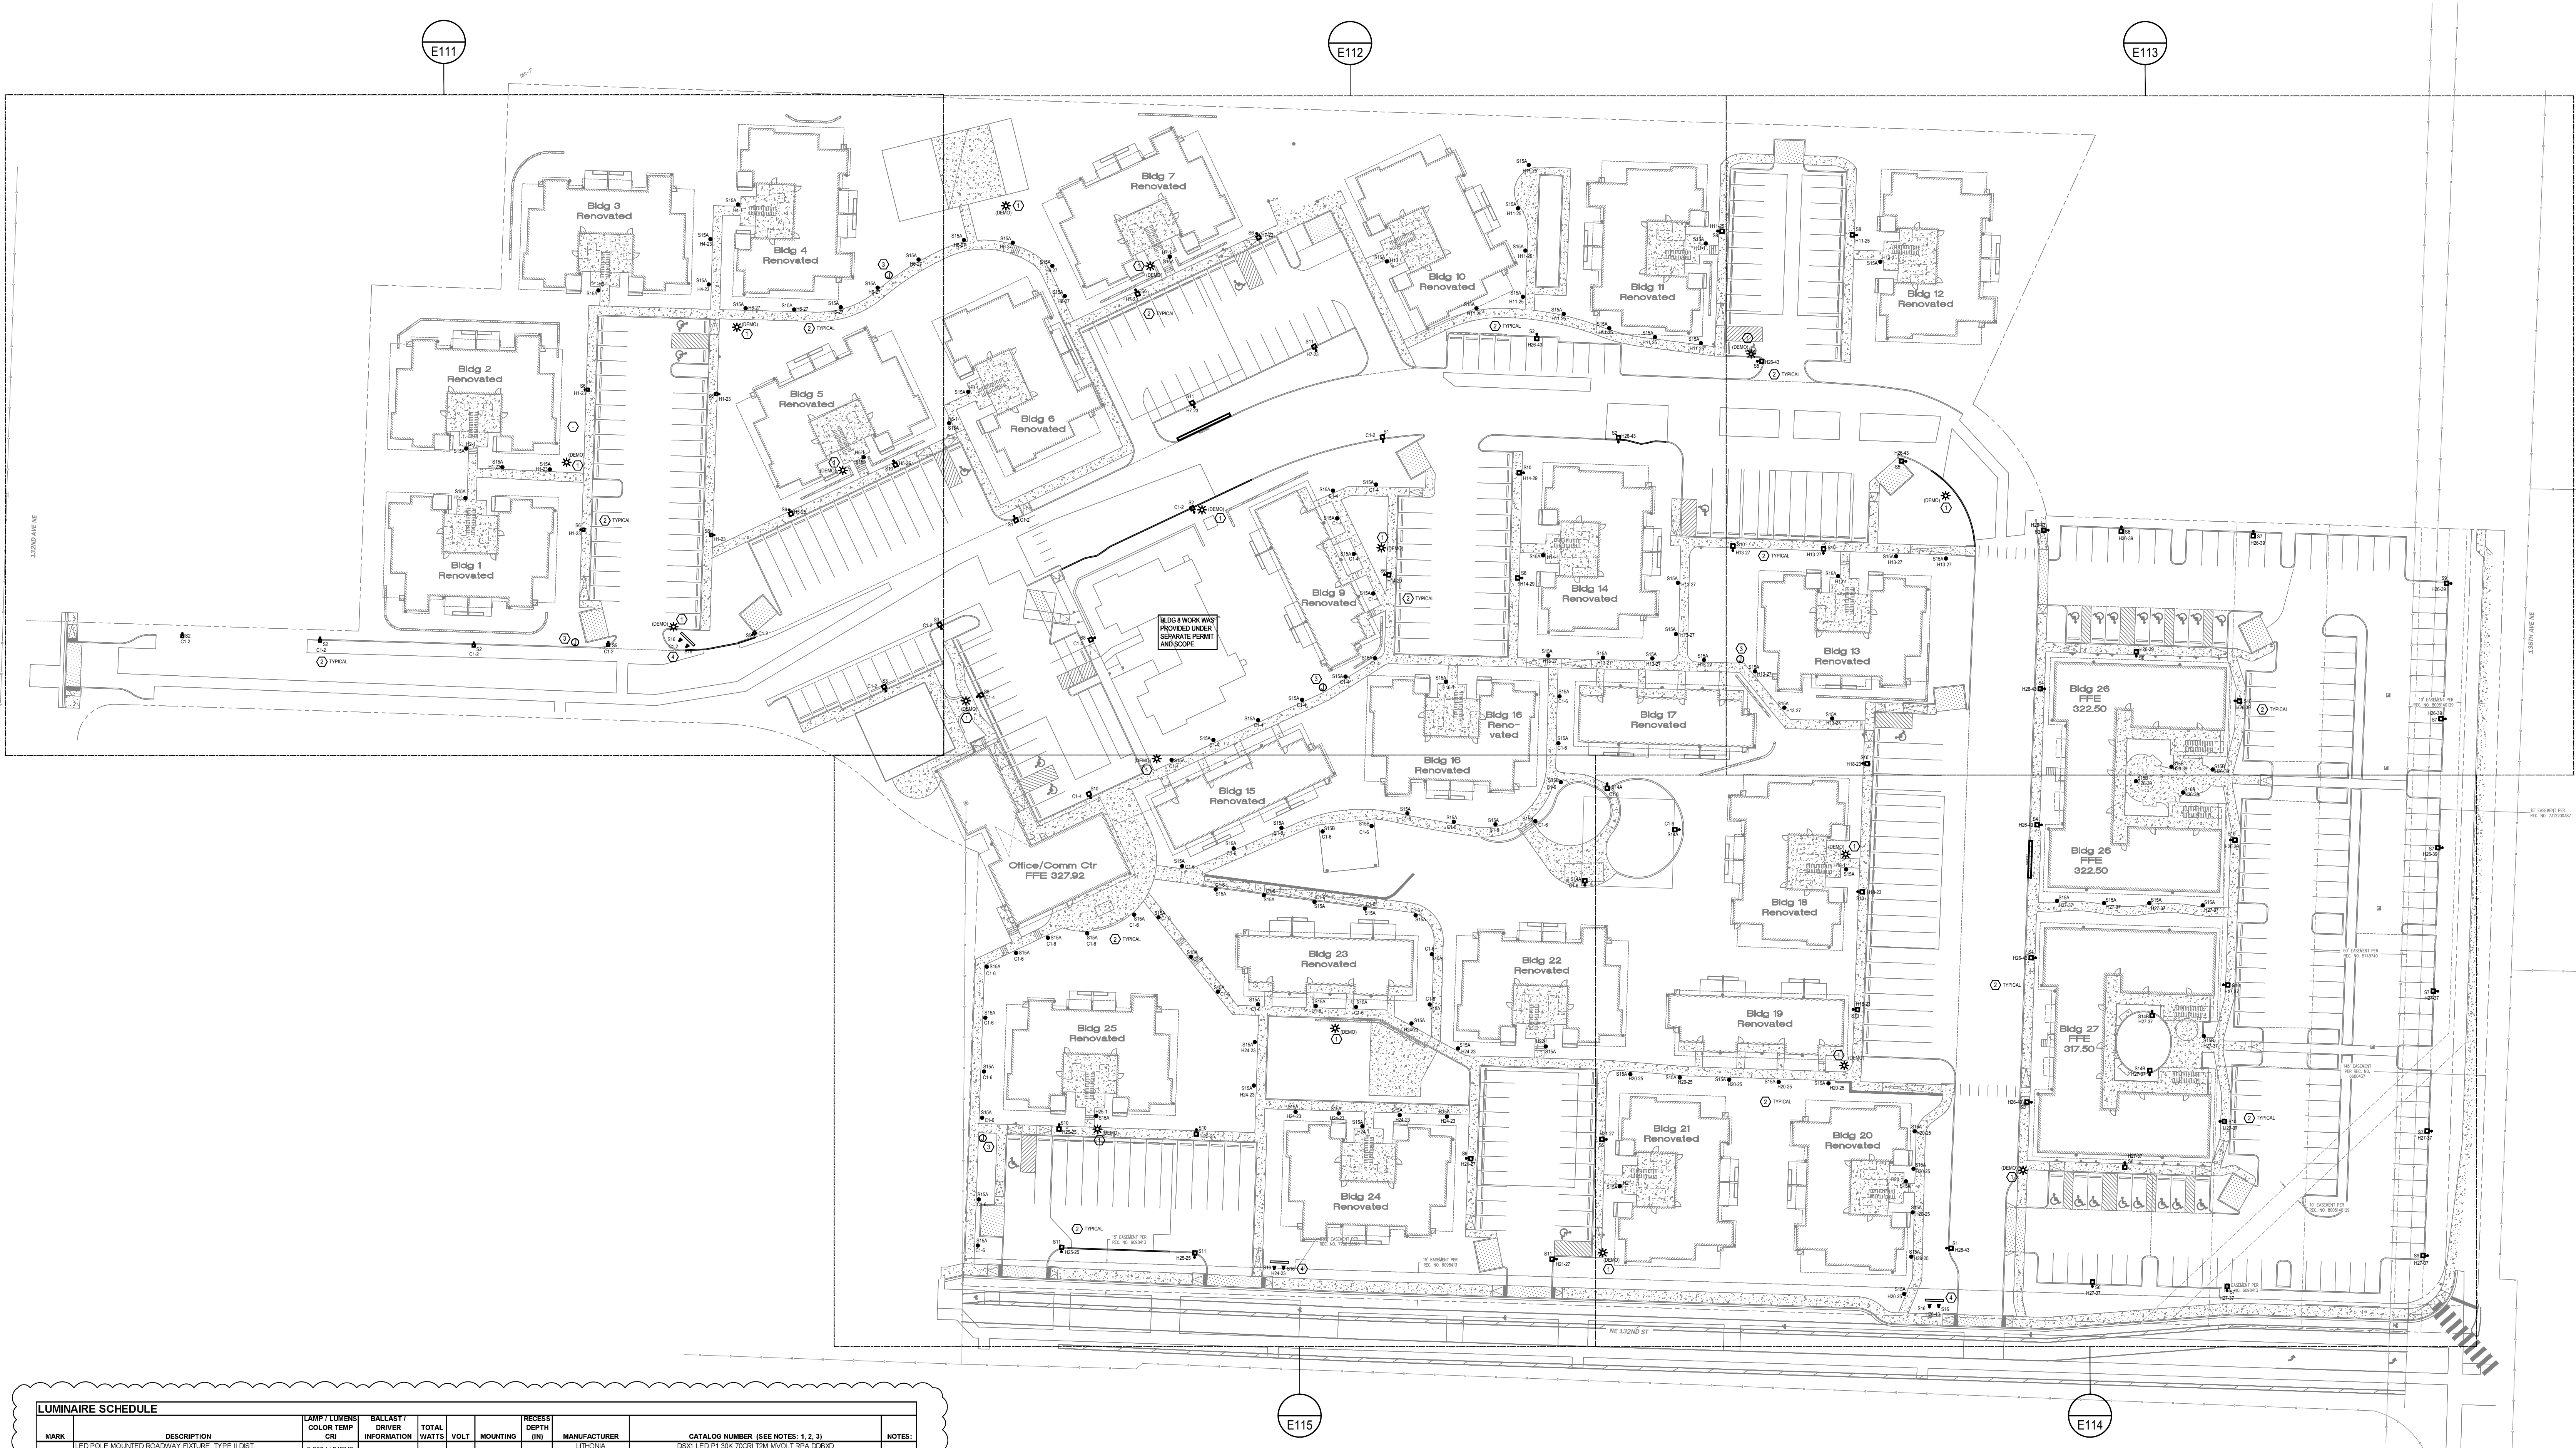

LUMINAIRE SCHEDULE

MARK	DESCRIPTION	LAMP / LUMENS COLOR TEMP CRI	BALLAST / DRIVER INFORMATION	TOTAL WATTS	VOLTS	MOUNTING	RECESS DEPTH IN	MANUFACTURER	CATALOG NUMBER (SEE NOTES: 1, 2, 3)	NOTES:
51	LED POLE MOUNTED ROADWAY LIGHT, TYPE I DIST, PROVIDE ROUND STEEL POLE, MOUNTING HEIGHT = 20-FEET AFF	7,200 LUMENS 3000K 70+	ELECTRONIC	52.0	120	POLE		LITHONIA U.S. ARCHITECTURAL McGRATH-EDISON	DSX1 LED P1 30K 70CR 120W 1M VOLT RFA R18 DSX02 R2RM / PLEDIV / FT1 / 48LED-3500K-A-30K / 120 / RAL-9005-T / HS-PL-ED GALN-SAGA-730-U-SL2-BK-HSS	
52	LED POLE MOUNTED ROADWAY LIGHT, TYPE I DIST, HOUSE-SIDE SHIELD, PROVIDE ROUND STEEL POLE, MOUNTING HEIGHT = 20-FEET AFF	7,200 LUMENS 3000K 70+	ELECTRONIC	52.0	120	POLE		LITHONIA U.S. ARCHITECTURAL McGRATH-EDISON	DSX1 LED P1 30K 70CR 120W 1M VOLT RFA R18 DSX02 R2RM / PLEDIV / FT1 / 48LED-3500K-A-30K / 120 / RAL-9005-T / HS-PL-ED GALN-SAGA-730-U-SL2-BK-HSS	
53	LED POLE MOUNTED ROADWAY LIGHT, TYPE II DIST, HOUSE-SIDE SHIELD, PROVIDE ROUND STEEL POLE, MOUNTING HEIGHT = 20-FEET AFF	7,200 LUMENS 3000K 70+	ELECTRONIC	52.0	120	POLE		LITHONIA U.S. ARCHITECTURAL McGRATH-EDISON	DSX1 LED P1 30K 70CR 120W 1M VOLT RFA R18 DSX02 R2RM / PLEDIV / FT1 / 48LED-3500K-A-30K / 120 / RAL-9005-T / HS-PL-ED GALN-SAGA-730-U-SL2-BK-HSS	
54	LED POLE MOUNTED ROADWAY LIGHT, TYPE II DIST, HOUSE-SIDE SHIELD, PROVIDE ROUND STEEL POLE, MOUNTING HEIGHT = 20-FEET AFF	7,200 LUMENS 3000K 70+	ELECTRONIC	52.0	120	POLE		LITHONIA U.S. ARCHITECTURAL McGRATH-EDISON	DSX1 LED P1 30K 70CR 120W 1M VOLT RFA R18 DSX02 R2RM / PLEDIV / FT1 / 48LED-3500K-A-30K / 120 / RAL-9005-T / HS-PL-ED GALN-SAGA-730-U-SL2-BK-HSS	
55	LED POLE MOUNTED ROADWAY LIGHT, TYPE V DIST, PROVIDE ROUND STEEL POLE, MOUNTING HEIGHT = 20-FEET AFF	7,200 LUMENS 3000K 70+	ELECTRONIC	52.0	120	POLE		LITHONIA U.S. ARCHITECTURAL McGRATH-EDISON	DSX1 LED P1 30K 70CR 120W 1M VOLT RFA R18 DSX02 R2RM / PLEDIV / FT1 / 48LED-3500K-A-30K / 120 / RAL-9005-T / HS-PL-ED GALN-SAGA-730-U-SL2-BK-HSS	
56	LED POLE MOUNTED ROADWAY LIGHT, TYPE II DIST, HOUSE-SIDE SHIELD, PROVIDE ROUND STEEL POLE, MOUNTING HEIGHT = 20-FEET AFF	7,200 LUMENS 3000K 70+	ELECTRONIC	52.0	120	POLE		LITHONIA U.S. ARCHITECTURAL McGRATH-EDISON	DSX1 LED P1 30K 70CR 120W 1M VOLT RFA R18 DSX02 R2RM / PLEDIV / FT1 / 48LED-3500K-A-30K / 120 / RAL-9005-T / HS-PL-ED GALN-SAGA-730-U-SL2-BK-HSS	
57	LED POLE MOUNTED PARKING LOT LIGHT, TYPE IV DIST, INTERNAL MOTION SENSOR FOR B-LEVEL DIMMING, PROVIDE ROUND STEEL POLE, MOUNTING HEIGHT = 20-FEET AFF	7,200 LUMENS 3000K 70+	ELECTRONIC	52.0	120	POLE		LITHONIA U.S. ARCHITECTURAL McGRATH-EDISON	DSX1 LED P1 30K 70CR 120W 1M VOLT RFA R18 DSX02 R2RM / PLEDIV / FT1 / 48LED-3500K-A-30K / 120 / RAL-9005-T / HS-PL-ED GALN-SAGA-730-U-SL2-BK-HSS	
58	LED POLE MOUNTED PARKING LOT LIGHT, TYPE IV DIST, HOUSE-SIDE SHIELD, PROVIDE ROUND STEEL POLE, MOUNTING HEIGHT = 20-FEET AFF	7,200 LUMENS 3000K 70+	ELECTRONIC	52.0	120	POLE		LITHONIA U.S. ARCHITECTURAL McGRATH-EDISON	DSX1 LED P1 30K 70CR 120W 1M VOLT RFA R18 DSX02 R2RM / PLEDIV / FT1 / 48LED-3500K-A-30K / 120 / RAL-9005-T / HS-PL-ED GALN-SAGA-730-U-SL2-BK-HSS	
59	LED POLE MOUNTED PARKING LOT LIGHT, TYPE IV DIST, INTERNAL MOTION SENSOR FOR B-LEVEL DIMMING, PROVIDE ROUND STEEL POLE, MOUNTING HEIGHT = 20-FEET AFF	7,200 LUMENS 3000K 70+	ELECTRONIC	52.0	120	POLE		LITHONIA U.S. ARCHITECTURAL McGRATH-EDISON	DSX1 LED P1 30K 70CR 120W 1M VOLT RFA R18 DSX02 R2RM / PLEDIV / FT1 / 48LED-3500K-A-30K / 120 / RAL-9005-T / HS-PL-ED GALN-SAGA-730-U-SL2-BK-HSS	
510	LED POLE MOUNTED PARKING LOT LIGHT, TYPE IV DIST, HOUSE-SIDE SHIELD, PROVIDE ROUND STEEL POLE, MOUNTING HEIGHT = 20-FEET AFF	7,200 LUMENS 3000K 70+	ELECTRONIC	52.0	120	POLE		LITHONIA U.S. ARCHITECTURAL McGRATH-EDISON	DSX1 LED P1 30K 70CR 120W 1M VOLT RFA R18 DSX02 R2RM / PLEDIV / FT1 / 48LED-3500K-A-30K / 120 / RAL-9005-T / HS-PL-ED GALN-SAGA-730-U-SL2-BK-HSS	
511	LED POLE MOUNTED PARKING LOT LIGHT, TYPE V DIST, INTERNAL MOTION SENSOR FOR B-LEVEL DIMMING, PROVIDE ROUND STEEL POLE, MOUNTING HEIGHT = 20-FEET AFF	7,200 LUMENS 3000K 70+	ELECTRONIC	52.0	120	POLE		LITHONIA U.S. ARCHITECTURAL McGRATH-EDISON	DSX1 LED P1 30K 70CR 120W 1M VOLT RFA R18 DSX02 R2RM / PLEDIV / FT1 / 48LED-3500K-A-30K / 120 / RAL-9005-T / HS-PL-ED GALN-SAGA-730-U-SL2-BK-HSS	
514A	LED POLE MOUNTED PEBBLETRAY AREA LIGHT, TYPE IV MEDIUM DISTRIBUTION, INTERNAL MOTION SENSOR FOR B-LEVEL DIMMING, PROVIDE ROUND STEEL POLE, MOUNTING HEIGHT = 12-FEET AFF	1,700 LUMENS 3000K 80+	ELECTRONIC	16.0		POLE		WE-EF NLS LIGHTING RAGN LIGHTING	VF132Z LED II-115760 NV-1-74-16L-25-30K-UNV-DPST**FSP-20RPA TENK-6-16-35-35-1-TPL1-T-48C	
514B	LED POLE MOUNTED PEBBLETRAY AREA LIGHT, TYPE II SHORT DISTRIBUTION, INTERNAL MOTION SENSOR FOR B-LEVEL DIMMING, PROVIDE ROUND STEEL POLE, MOUNTING HEIGHT = 12-FEET AFF	1,700 LUMENS 3000K 80+	ELECTRONIC	16.0		POLE		WE-EF NLS LIGHTING RAGN LIGHTING	VF132Z LED II-115760 NV-1-74-16L-25-30K-UNV-DPST**FSP-20RPA TENK-6-16-35-35-1-TPL1-T-48C	
515A	GRADE MOUNTED LED BOLLARD LIGHT, PROTECTED LENS, ASYMMETRIC DISTRIBUTION, 36-INCH TALL	500 LUMENS 3000K 80+	ELECTRONIC	14.0	120	GRADE		WE-EF LITHONIA McGRATH-EDISON	MRT22Z LED II-115760 RABD LED P3 30K 51W VOLT 815 BCF H8 DSX02 BRTM-A1-730-U-75-36-BK	
515B	GRADE MOUNTED LED BOLLARD LIGHT, PROTECTED LENS, SYMMETRIC DISTRIBUTION, 36-INCH TALL	500 LUMENS 3000K 80+	ELECTRONIC	14.0	120	GRADE		WE-EF LITHONIA McGRATH-EDISON	MRT22Z LED II-115760 RABD LED P3 30K 51W VOLT 815 BCF H8 DSX02 BRTM-A1-730-U-75-36-BK	
516	LANDSCAPE ACCENT LIGHT, ADJUSTABLE BEAM FLOODLIGHT WITH 40-DEGREE BEAM SPREAD, PROVIDE WITH GROUND SPIKE	550 LUMENS 3000K 70+	ELECTRONIC OR LOW-VOLTAGE	10.0	120	GRADE		NEW LITE INC. LUNA LIGHTING ECONOMIE LTD	FL2003-40 / 40 / FLOOD / 4W / WHITE / 3000K / 120 / BLACK / GROUND SPIKE FLOOD-RAND-300-40-40-C	

NOTES:
1. PROVIDE ALL PARTS, COMPONENTS, AND HARDWARE TO CONSTITUTE A COMPLETE INSTALLATION WITH OPTIONS INDICATED IN LUMINAIRE SCHEDULE. CATALOG NUMBERS FOR SUCH ITEMS ARE NOT INCLUDED IN SCHEDULE ABOVE.
2. COORDINATE ALL COLORS / FINISHES WITH ARCHITECT.

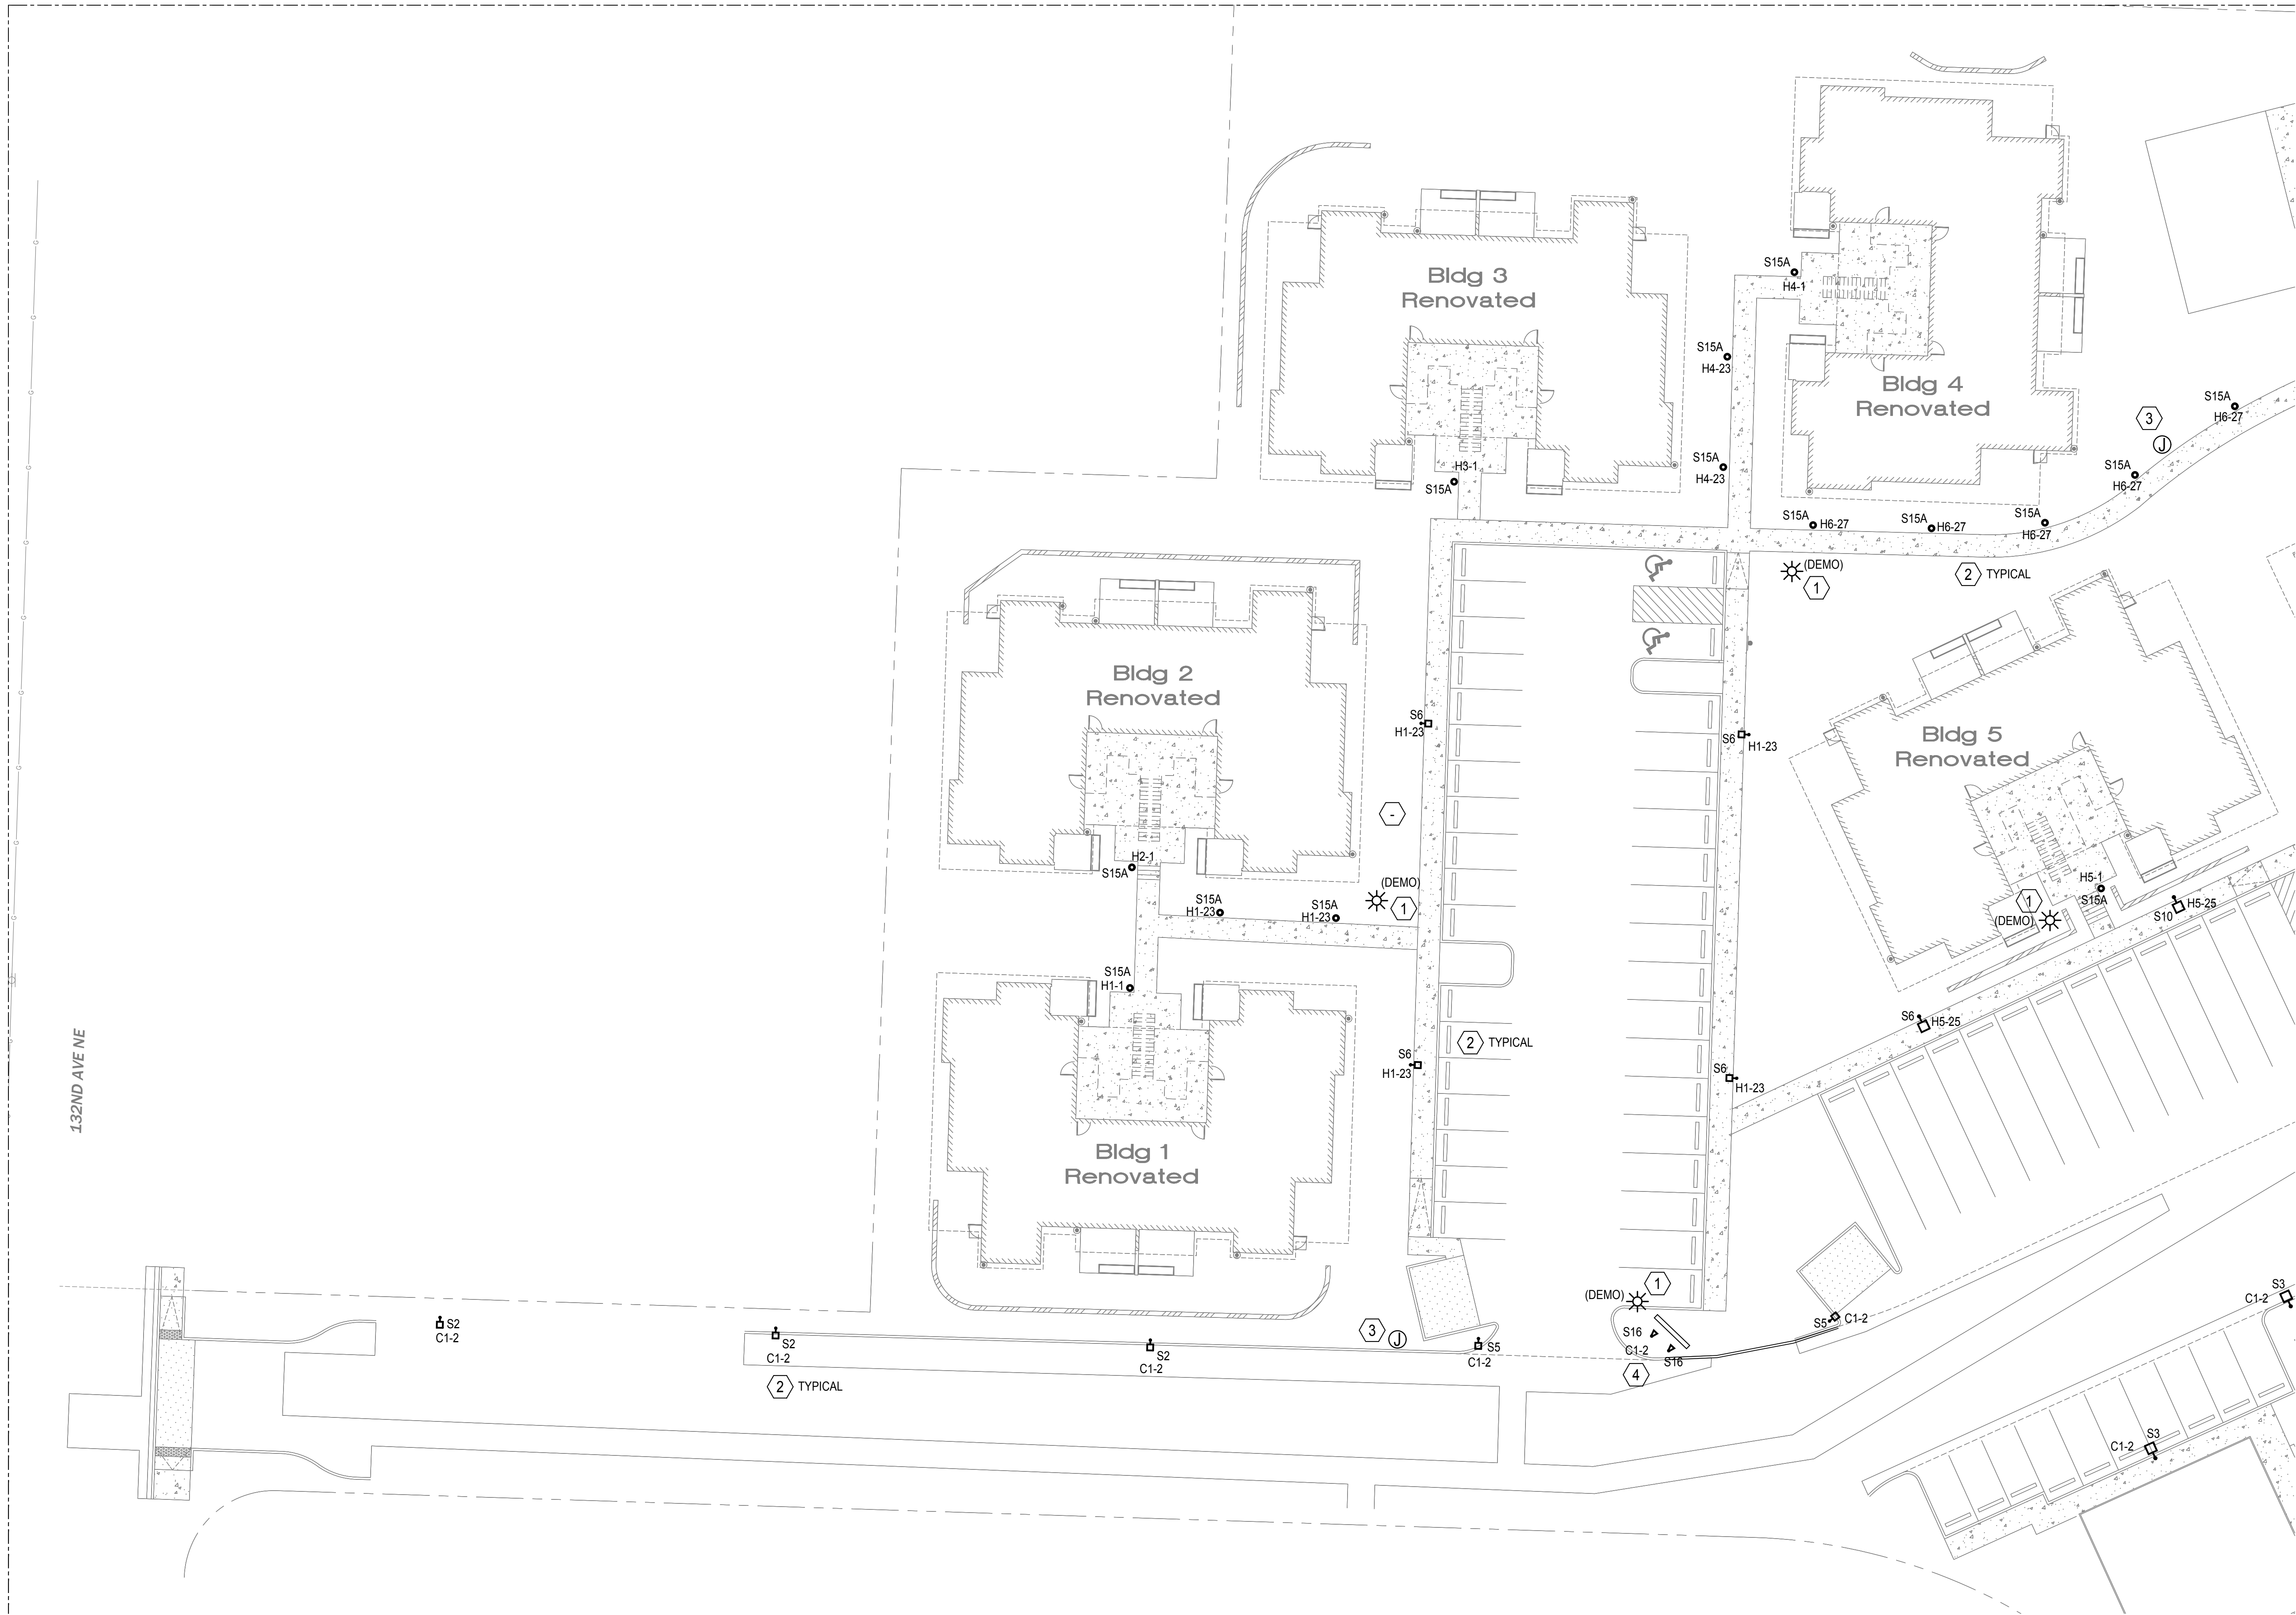

SITE LIGHTING PLAN - SECTION 1

SCALE: 1"=20'-0"

GENERAL NOTES:

- ALL POLE MOUNTED FIXTURES HAVE A MAX MOUNTING HEIGHT OF 20- FEET ABOVE GRADE PER CITY OF KIRKLAND REQUIREMENTS.
- MINIMUM WIRE SIZE FOR ALL SITE LIGHTING BRANCH CIRCUITRY TO BE #10 AWG COPPER. CONTRACTOR TO VERIFY VOLTAGE DROP ON CIRCUITS BASED ON FINAL FIXTURE PLACEMENT AND UPSIZE CONDUCTORS AS NECESSARY TO MEET CODE.
- PROVIDE IN-GRADE JUNCTION BOX AT EACH POLE MOUNTED AREA & ROADWAY LIGHT FOR BRANCH CIRCUIT CONNECTIONS TO POLE BASE.

FLAG NOTES (X):

- EXISTING LIGHT POLE TO BE DEMOLISHED. FEEDING BRANCH CIRCUIT CABLING TO BE DEMOLISHED OR DISCONNECTED AND MADE SAFE WHERE ABANDONED IN PLACE.
- ALL NEW SITE LIGHTING FIXTURES TO HAVE AUTOMATIC TIMECLOCK ON/OFF ACTIVATION BY LIGHTING CONTROL PANEL (LCP) LOCATED IN THE BUILDING SERVING THE INDICATED BRANCH CIRCUITS. SEE INDIVIDUAL BUILDING DESIGN SHEETS FOR LCP RELAY SCHEDULE AND MORE INFORMATION.
- PROVIDE IN-GRADE JUNCTION BOX FOR EXTENDING LIGHTING BRANCH CIRCUIT TO FIXTURES LOCATED WITHIN DIFFERENT PHASES OF PROJECT CONSTRUCTION.
- GRADE MOUNTED FLOOR LIGHT(S) FOR MONUMENT SIGN(S). PROVIDE WEATHER-PROOF, IN-GRADE JUNCTION BOX, CAPABLE OF HOUSING THE LOW-VOLTAGE POWER SUPPLY FOR FIXTURES, WITH CONDUIT PATHWAY FROM J-BOX TO FIXTURE HEAD FOR CABLING CONNECTIONS.



192 Nickerson, Suite #300
Seattle, Washington 98109
Phone: 206.285.2966

SMR Architects
117 S. Main St., Suite 400
Seattle, WA 98104

PH: 206.623.1104
FX: 206.623.5285



New Kirkland Heights LLLP
c/o: King County Housing Authority,
General Partner
13310 NE 133rd St.
Kirkland, WA 98034.
CONTRACT #: TC2300131

KIRKLAND HEIGHTS APARTMENTS

13324 NE 132nd St.,
Kirkland, WA 98034

SITE ELECTRICAL INFRASTRUCTURE BID SET



REVISIONS / NOTES		
NO	DATE	DESCRIPTION
1	5.19.23	BID ADDENDUM 2


DPD STAMP

TITLE

SITE LIGHTING PLAN - SECTION 1

PERMIT #	
DRAWN	RA, JF
CHECKED	GL
ISSUE DATE	04/14/2023
JOB NO.	22014
SHEET NO.:	

E111

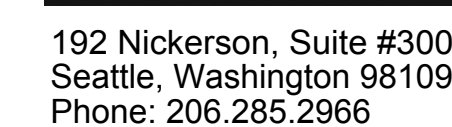

PH: 206.623.1104
FX: 206.623.5285



13324 NE 132nd St.,
Kirkland, WA 98034

DPD STAMP

TITLE

SITE LIGHTING
PLAN -
SECTION 2

PERMIT #	
DRAWN	RA, JF
CHECKED	GL
ISSUE DATE	04/14/2023
JOB NO.	22014
SHEET NO.:	

E112



 **SITE LIGHTING PLAN - SECTION 2**
SCALE: 1"=20'-0"

- A. ALL POLE MOUNTED FIXTURES HAVE A MAX MOUNTING HEIGHT OF 20-FEET ABOVE GRADE PER CITY OF KIRKLAND REQUIREMENTS.
- B. MINIMUM WIRE SIZE FOR ALL SITE LIGHTING BRANCH CIRCUITRY TO BE #10 AWG COPPER. CONTRACTOR TO VERIFY VOLTAGE DROP ON CIRCUITS BASED ON FINAL FIXTURE PLACEMENT AND UPSIZE CONDUCTORS AS NECESSARY TO MEET CODE.
- C. PROVIDE IN-GRADE JUNCTION BOX AT EACH POLE MOUNTED AREA & ROADWAY LIGHT FOR BRANCH CIRCUIT CONNECTIONS TO POLE FEASE.

1. EXISTING LIGHT POLE TO BE DEMOLISHED. FEEDING BRANCH CIRCUIT CABLEING TO BE DEMOLISHED OR DISCONNECTED AND MADE SAFE WHERE ABANDONED IN PLACE.
2. ALL NEW SITE LIGHTING FIXTURES TO HAVE AUTOMATIC TIMECLOCK ON/OFF ACTIVATION BY LIGHTING CONTROL PANEL (LCP) LOCATED IN THE BUILDING SERVING THE INDICATED BRANCH CIRCUITS. SEE INDIVIDUAL BUILDING DESIGN SHEETS FOR LCP RELAY SCHEDULE AND MORE INFORMATION.
3. PROVIDE IN-GRADE JUNCTION BOX FOR EXTENDING LIGHTING BRANCH CIRCUIT TO FIXTURES LOCATED WITHIN DIFFERENT PHASES OF PROJECT CONSTRUCTION.
4. GRADE MOUNTED FLOOR LIGHT(S) FOR MONUMENT SIGN(S). PROVIDE WEATHER-PROOF, IN-GRADE JUNCTION BOX, CAPABLE OF HOUSING THE LOW-VOLTAGE POWER SUPPLY FOR FIXTURES, WITH CONDUIT PATHWAY FROM J-BOX TO FIXTURE HEAD FOR CABLEING CONNECTIONS.



192 Nickerson, Suite #300
Seattle, Washington 98109
Phone: 206.285.2966

SMR Architects
117 S. Main St., Suite 400
Seattle, WA 98104

PH: 206.623.1104
FX: 206.623.5285



New Kirkland Heights LLLP
c/o: King County Housing Authority,
General Partner
13310 NE 133rd St.
Kirkland, WA 98034
CONTRACT #: TC2300131

KIRKLAND HEIGHTS APARTMENTS

13324 NE 132nd St.,
Kirkland, WA 98034

SITE ELECTRICAL INFRASTRUCTURE BID SET



REVISIONS / NOTES		
NO	DATE	DESCRIPTION
1	5.19.23	BID ADDENDUM 2



DPD STAMP

TITLE

SITE LIGHTING PLAN - SECTION 3

PERMIT #	
DRAWN	RA, JF
CHECKED	GL
ISSUE DATE	04/14/2023
JOB NO.	22014
SHEET NO.:	

E113

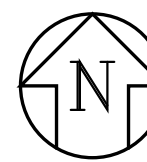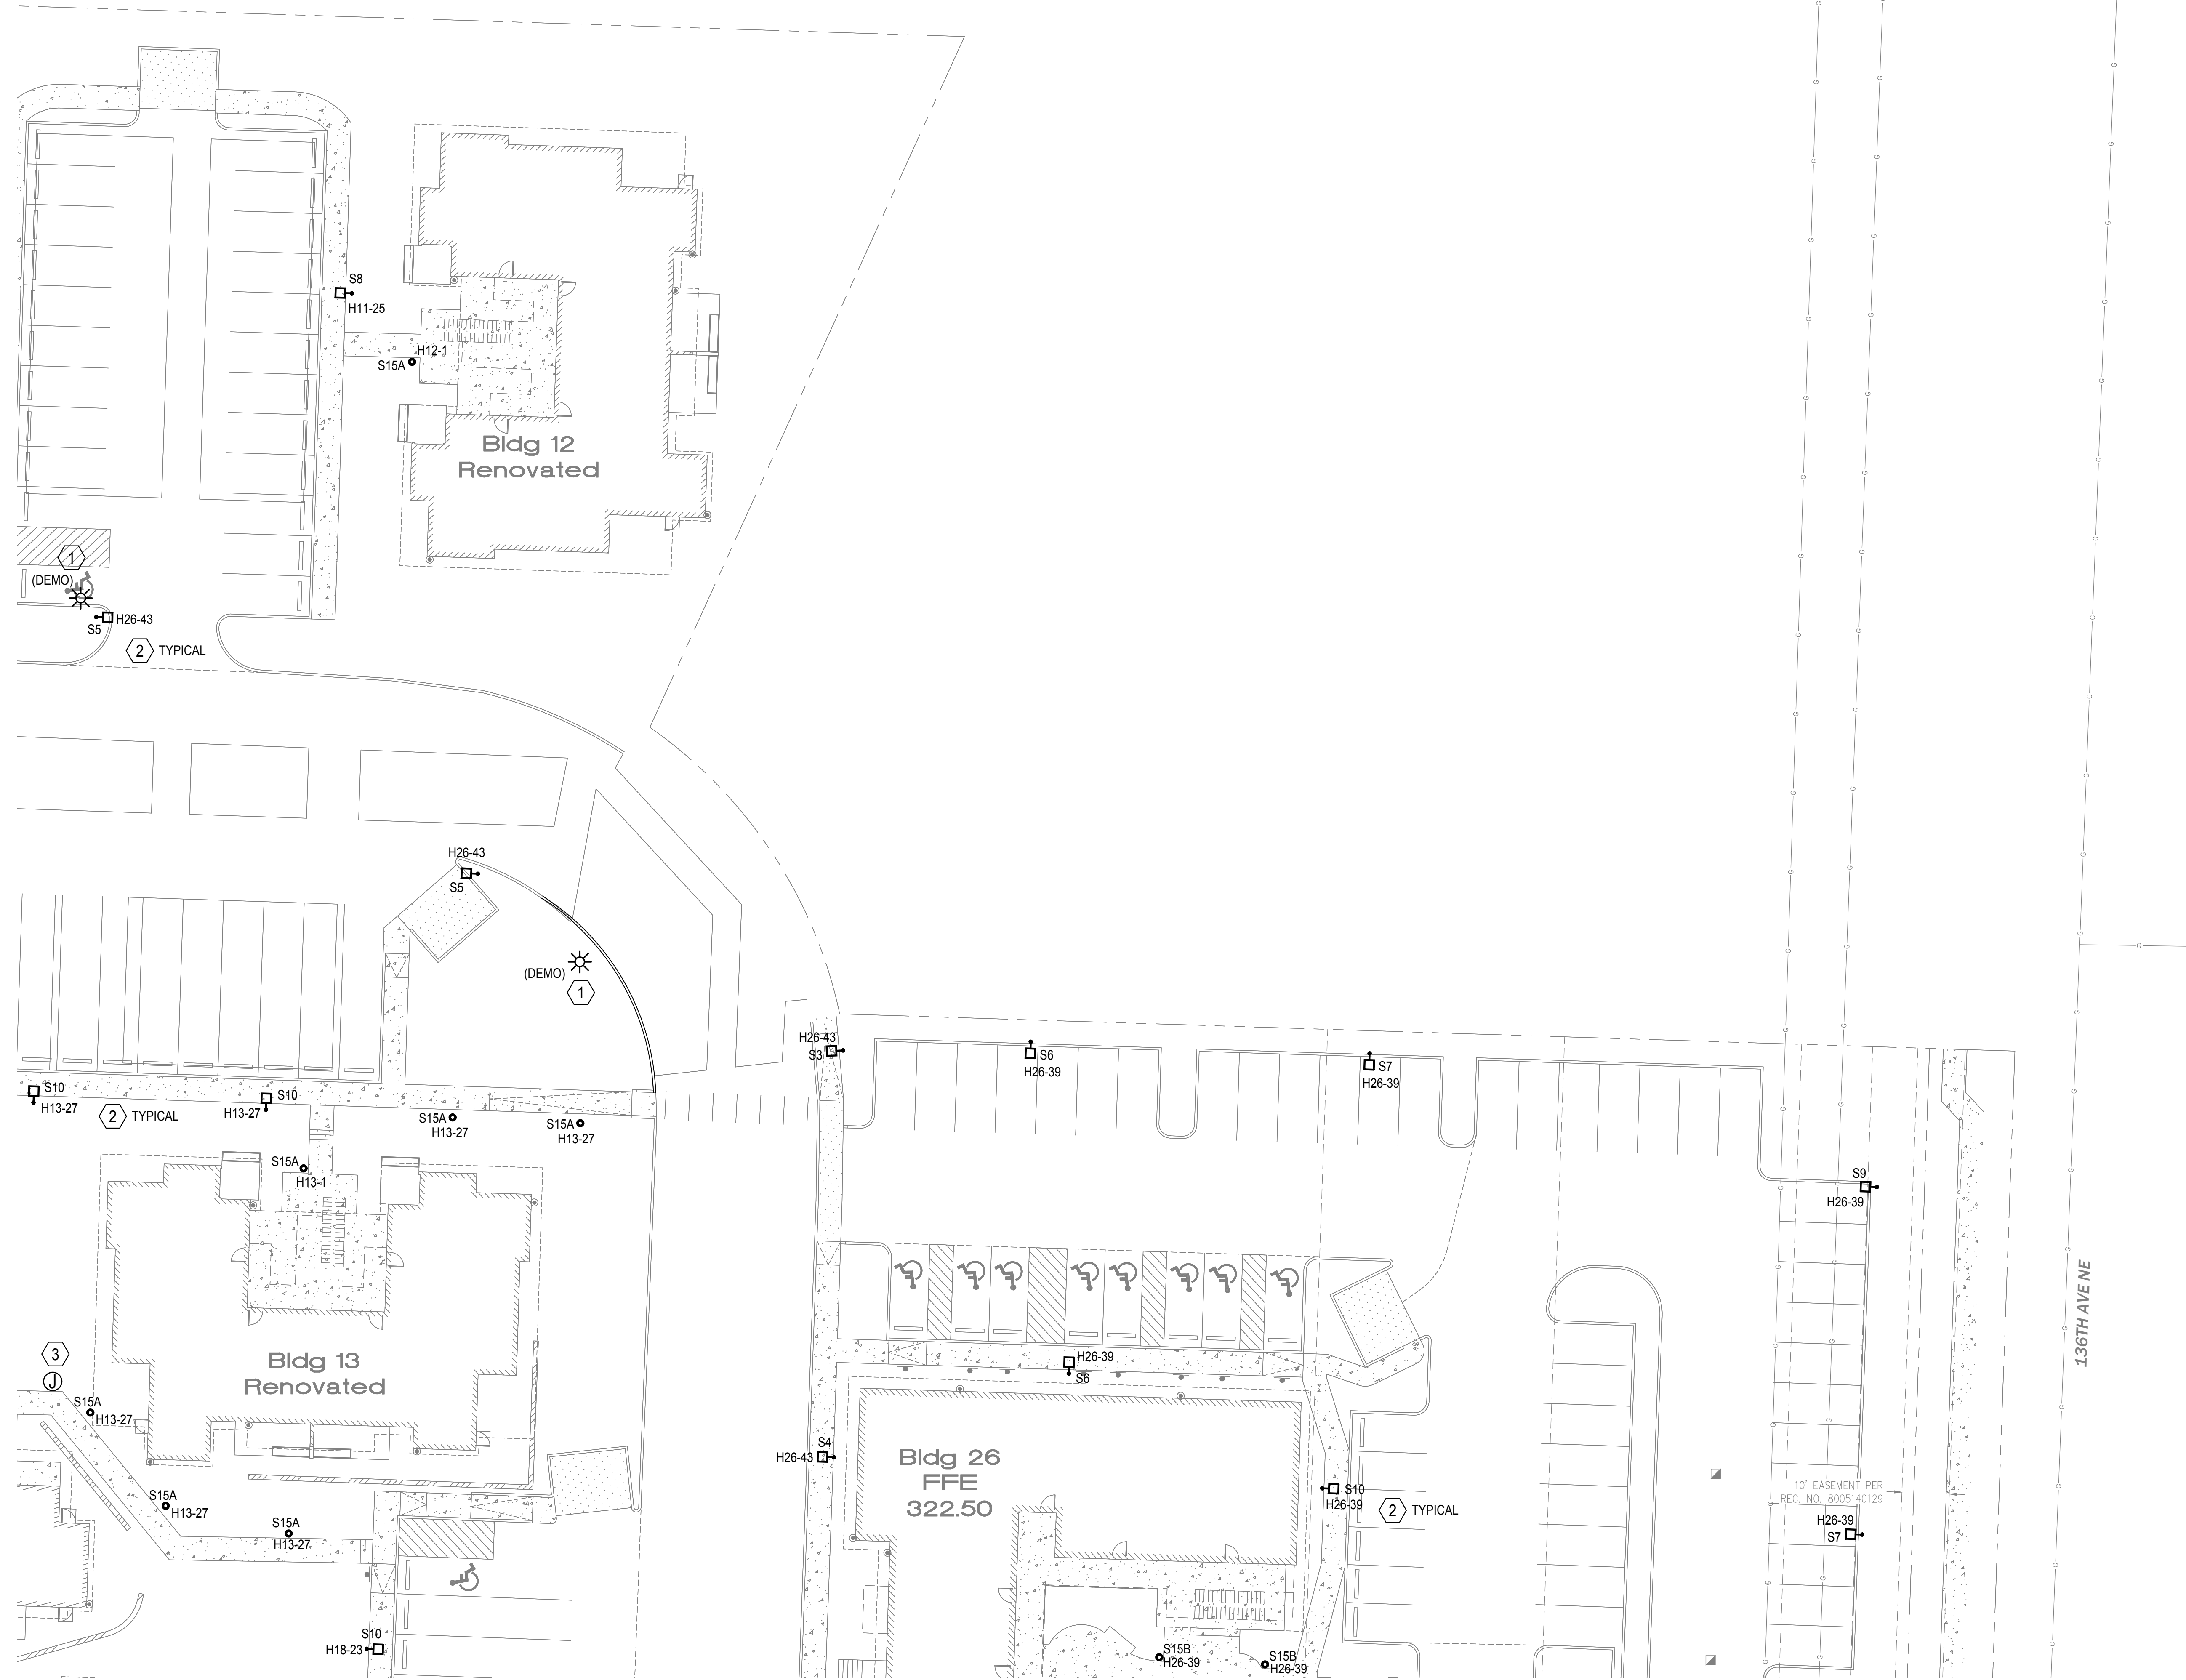

SITE LIGHTING PLAN - SECTION 3

SCALE: 1"=20'-0"

- GENERAL NOTES:**
- ALL POLE MOUNTED FIXTURES HAVE A MAX MOUNTING HEIGHT OF 20-FEET ABOVE GRADE PER CITY OF KIRKLAND REQUIREMENTS.
 - MINIMUM WIRE SIZE FOR ALL SITE LIGHTING BRANCH CIRCUITRY TO BE #10 AWG COPPER. CONTRACTOR TO VERIFY VOLTAGE DROP ON CIRCUITS BASED ON FINAL FIXTURE PLACEMENT AND UPSIZE CONDUCTORS AS NECESSARY TO MEET CODE.
 - PROVIDE IN-GRADE JUNCTION BOX AT EACH POLE MOUNTED AREA & ROADWAY LIGHT FOR BRANCH CIRCUIT CONNECTIONS TO POLE BASE.

- FLAG NOTES (X):**
- EXISTING LIGHT POLE TO BE DEMOLISHED. FEEDING BRANCH CIRCUIT CABLING TO BE DEMOLISHED OR DISCONNECTED AND MADE SAFE WHERE ABANDONED IN PLACE.
 - ALL NEW SITE LIGHTING FIXTURES TO HAVE AUTOMATIC TIMECLOCK ON/OFF ACTIVATION BY LIGHTING CONTROL PANEL (LCP) LOCATED IN THE BUILDING SERVING THE INDICATED BRANCH CIRCUITS. SEE INDIVIDUAL BUILDING DESIGN SHEETS FOR LCP RELAY SCHEDULE AND MORE INFORMATION.
 - PROVIDE IN-GRADE JUNCTION BOX FOR EXTENDING LIGHTING BRANCH CIRCUIT TO FIXTURES LOCATED WITHIN DIFFERENT PHASES OF PROJECT CONSTRUCTION.
 - GRADE MOUNTED FLOOR LIGHT(S) FOR MONUMENT SIGN(S). PROVIDE WEATHER-PROOF, IN-GRADE JUNCTION BOX, CAPABLE OF HOUSING THE LOW-VOLTAGE POWER SUPPLY FOR FIXTURES, WITH CONDUIT PATHWAY FROM J-BOX TO FIXTURE HEAD FOR CABLING CONNECTIONS.



192 Nickerson, Suite #300
Seattle, Washington 98109
Phone: 206.285.2966

SMR Architects
117 S. Main St., Suite 400
Seattle, WA 98104

PH: 206.623.1104
FX: 206.623.5285



New Kirkland Heights LLLP
c/o: King County Housing Authority,
General Partner
13310 NE 133rd St.
Kirkland, WA 98034.
CONTRACT #: TC2300131

KIRKLAND HEIGHTS APARTMENTS

13324 NE 132nd St.,
Kirkland, WA 98034

SITE ELECTRICAL INFRASTRUCTURE BID SET



REVISIONS / NOTES		
NO	DATE	DESCRIPTION
1	5.19.23	BID ADDENDUM 2


DPD STAMP

TITLE

SITE LIGHTING PLAN - SECTION 4

PERMIT #	
DRAWN	RA, JF
CHECKED	GL
ISSUE DATE	04/14/2023
JOB NO.	22014
SHEET NO.:	

E114

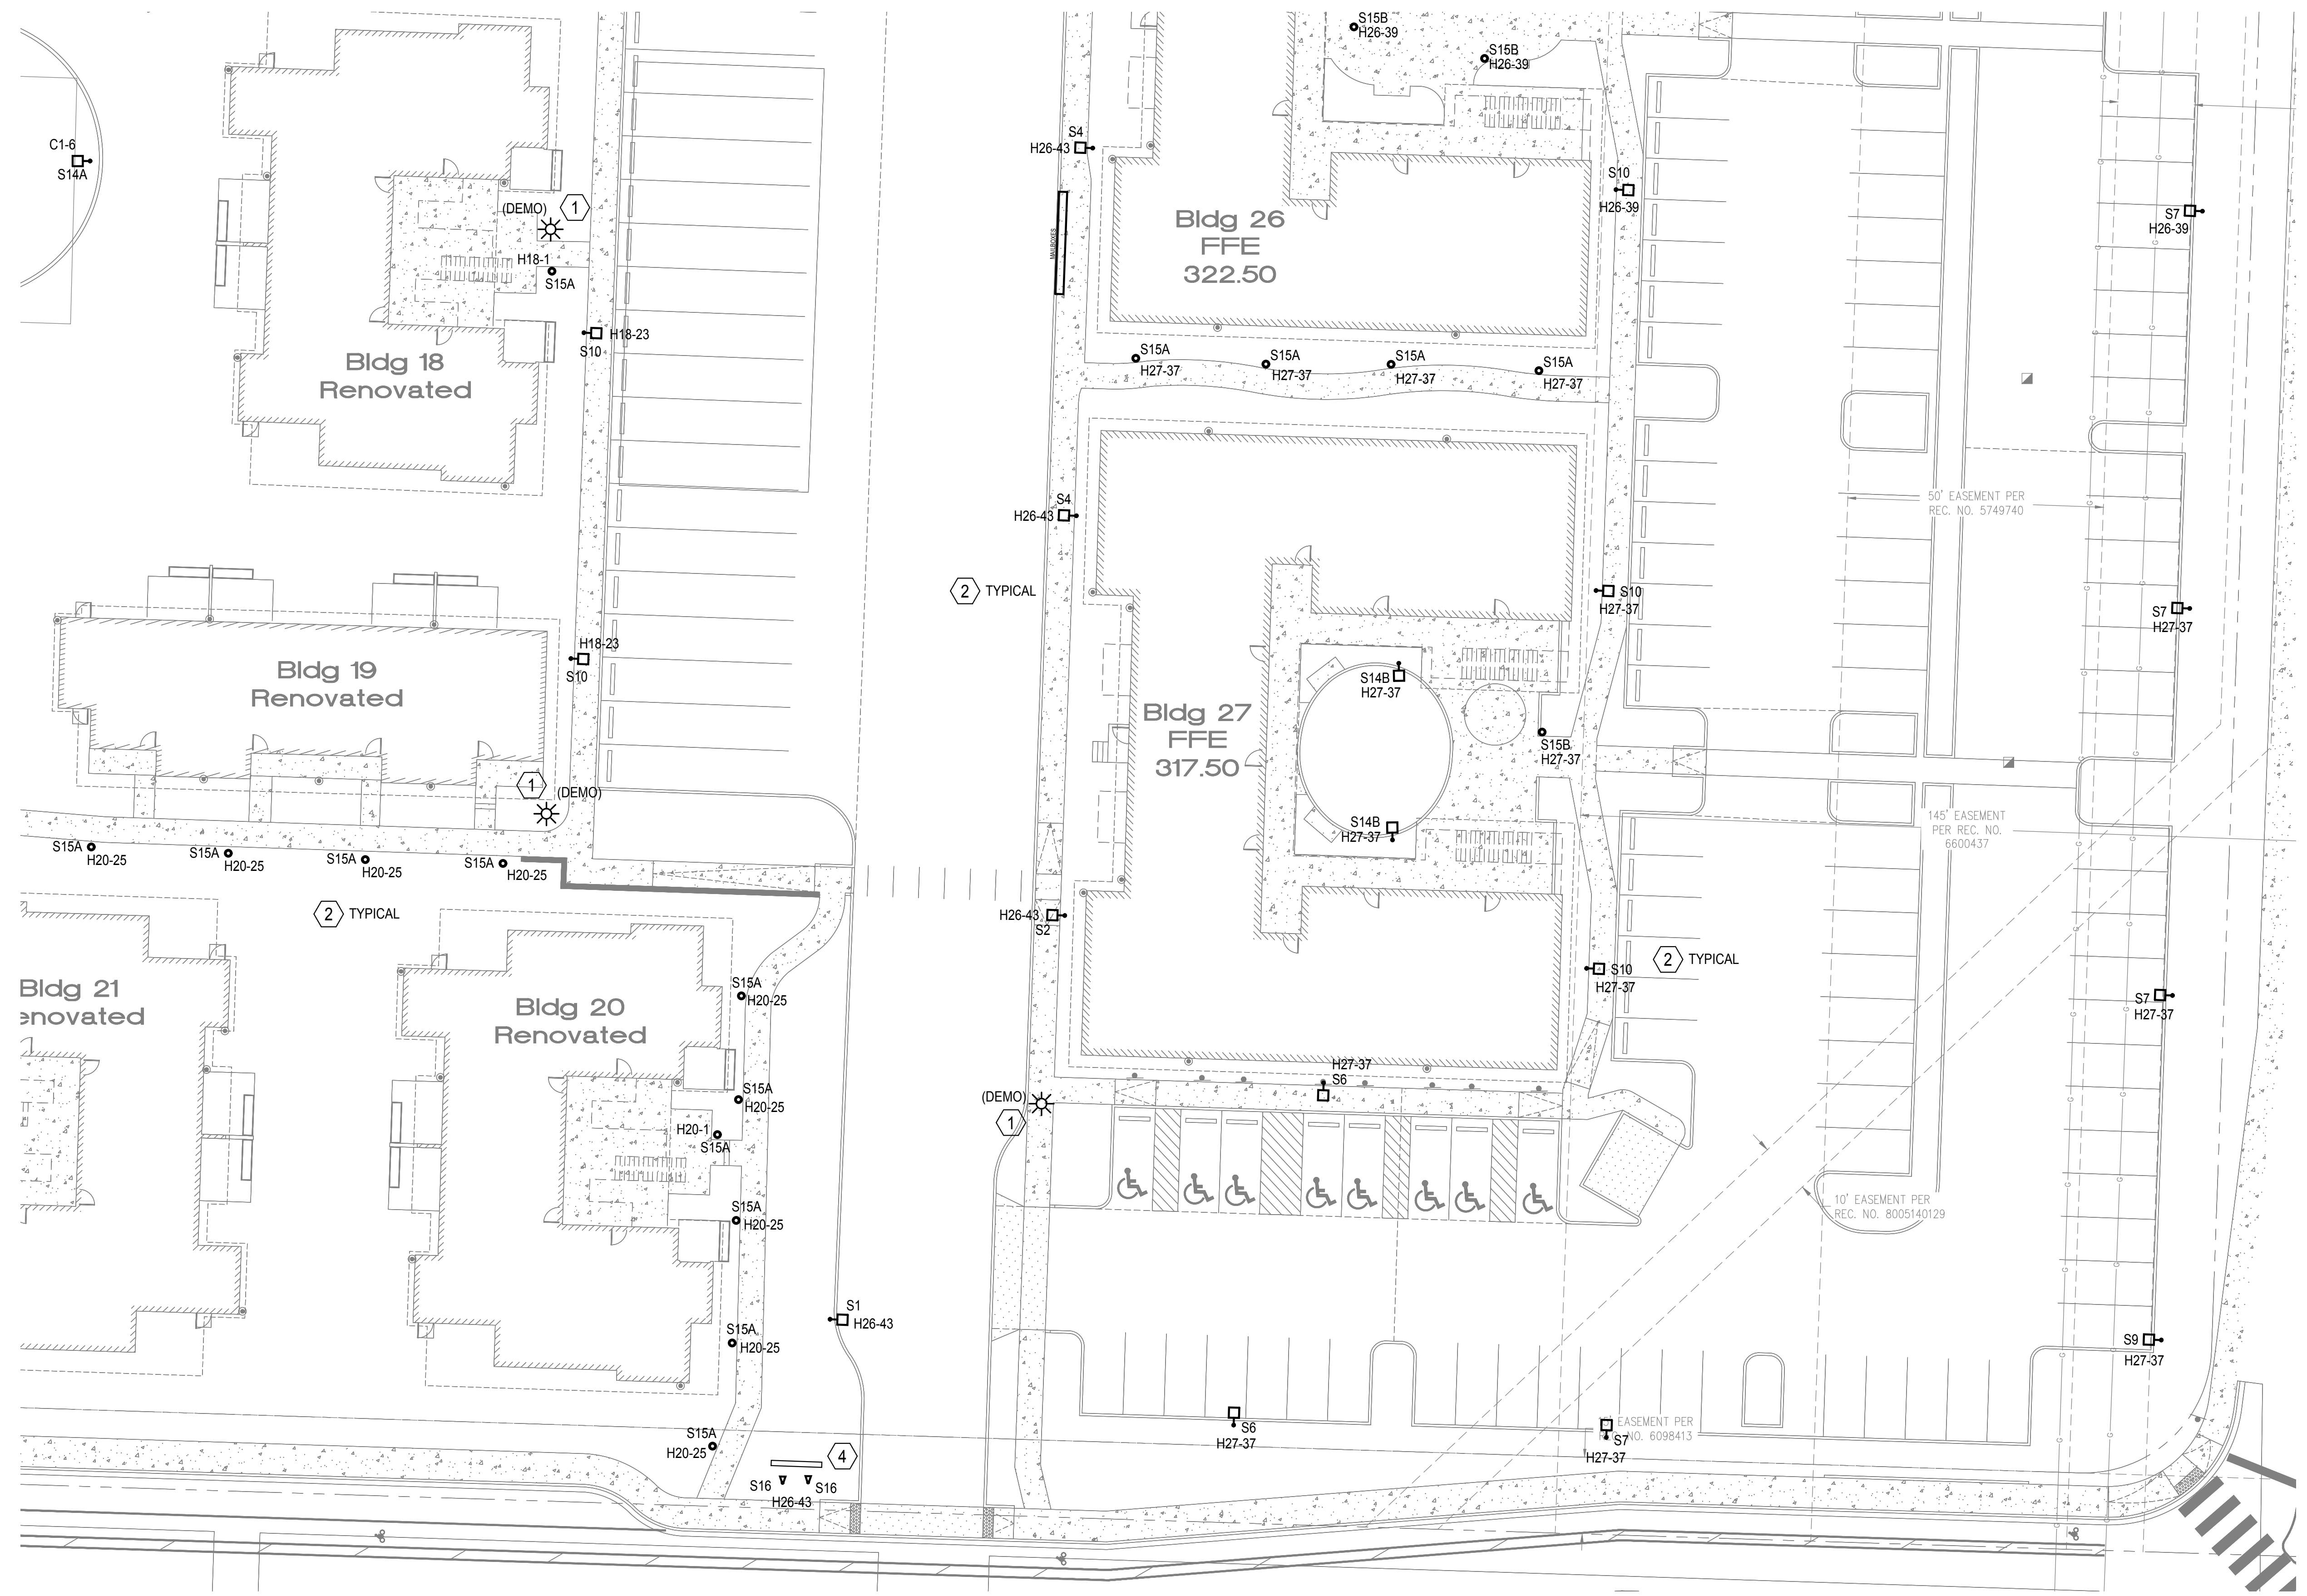

SITE LIGHTING PLAN - SECTION 4

SCALE: 1"=20'-0"

- GENERAL NOTES:**
- ALL POLE MOUNTED FIXTURES HAVE A MAX MOUNTING HEIGHT OF 20- FEET ABOVE GRADE PER CITY OF KIRKLAND REQUIREMENTS.
 - MINIMUM WIRE SIZE FOR ALL SITE LIGHTING BRANCH CIRCUITRY TO BE #10 AWG COPPER. CONTRACTOR TO VERIFY VOLTAGE DROP ON CIRCUITS BASED ON FINAL FIXTURE PLACEMENT AND UPSIZE CONDUCTORS AS NECESSARY TO MEET CODE.
 - PROVIDE IN-GRADE JUNCTION BOX AT EACH POLE MOUNTED AREA & ROADWAY LIGHT FOR BRANCH CIRCUIT CONNECTIONS TO POLE BASE.

- FLAG NOTES (X):**
- EXISTING LIGHT POLE TO BE DEMOLISHED. FEEDING BRANCH CIRCUIT CABLING TO BE DEMOLISHED OR DISCONNECTED AND MADE SAFE WHERE ABANDONED IN PLACE.
 - ALL NEW SITE LIGHTING FIXTURES TO HAVE AUTOMATIC TIMECLOCK ON/OFF ACTIVATION BY LIGHTING CONTROL PANEL (LCP) LOCATED IN THE BUILDING SERVING THE INDICATED BRANCH CIRCUITS. SEE INDIVIDUAL BUILDING DESIGN SHEETS FOR LCP RELAY SCHEDULE AND MORE INFORMATION.
 - PROVIDE IN-GRADE JUNCTION BOX FOR EXTENDING LIGHTING BRANCH CIRCUIT TO FIXTURES LOCATED WITHIN DIFFERENT PHASES OF PROJECT CONSTRUCTION.
 - GRADE MOUNTED FLOOR LIGHT(S) FOR MONUMENT SIGN(S). PROVIDE WEATHER-PROOF, IN-GRADE JUNCTION BOX, CAPABLE OF HOUSING THE LOW-VOLTAGE POWER SUPPLY FOR FIXTURES, WITH CONDUIT PATHWAY FROM J-BOX TO FIXTURE HEAD FOR CABLING CONNECTIONS.



192 Nickerson, Suite #300
Seattle, Washington 98109
Phone: 206.285.2966

SMR Architects
117 S. Main St., Suite 400
Seattle, WA 98104

PH: 206.623.1104
FX: 206.623.5285



New Kirkland Heights LLLP
c/o: King County Housing Authority,
General Partner
13310 NE 133rd St.
Kirkland, WA 98034.
CONTRACT #: TC2300131

KIRKLAND HEIGHTS APARTMENTS

13324 NE 132nd St.,
Kirkland, WA 98034

SITE ELECTRICAL INFRASTRUCTURE BID SET



REVISIONS / NOTES		
NO	DATE	DESCRIPTION
1	5.19.23	BID ADDENDUM 2

DPD STAMP



TITLE

SITE LIGHTING PLAN - SECTION 5

PERMIT #	
DRAWN	RA, JF
CHECKED	GL
ISSUE DATE	04/14/2023
JOB NO.	22014

SHEET NO.:

E115

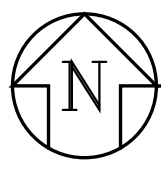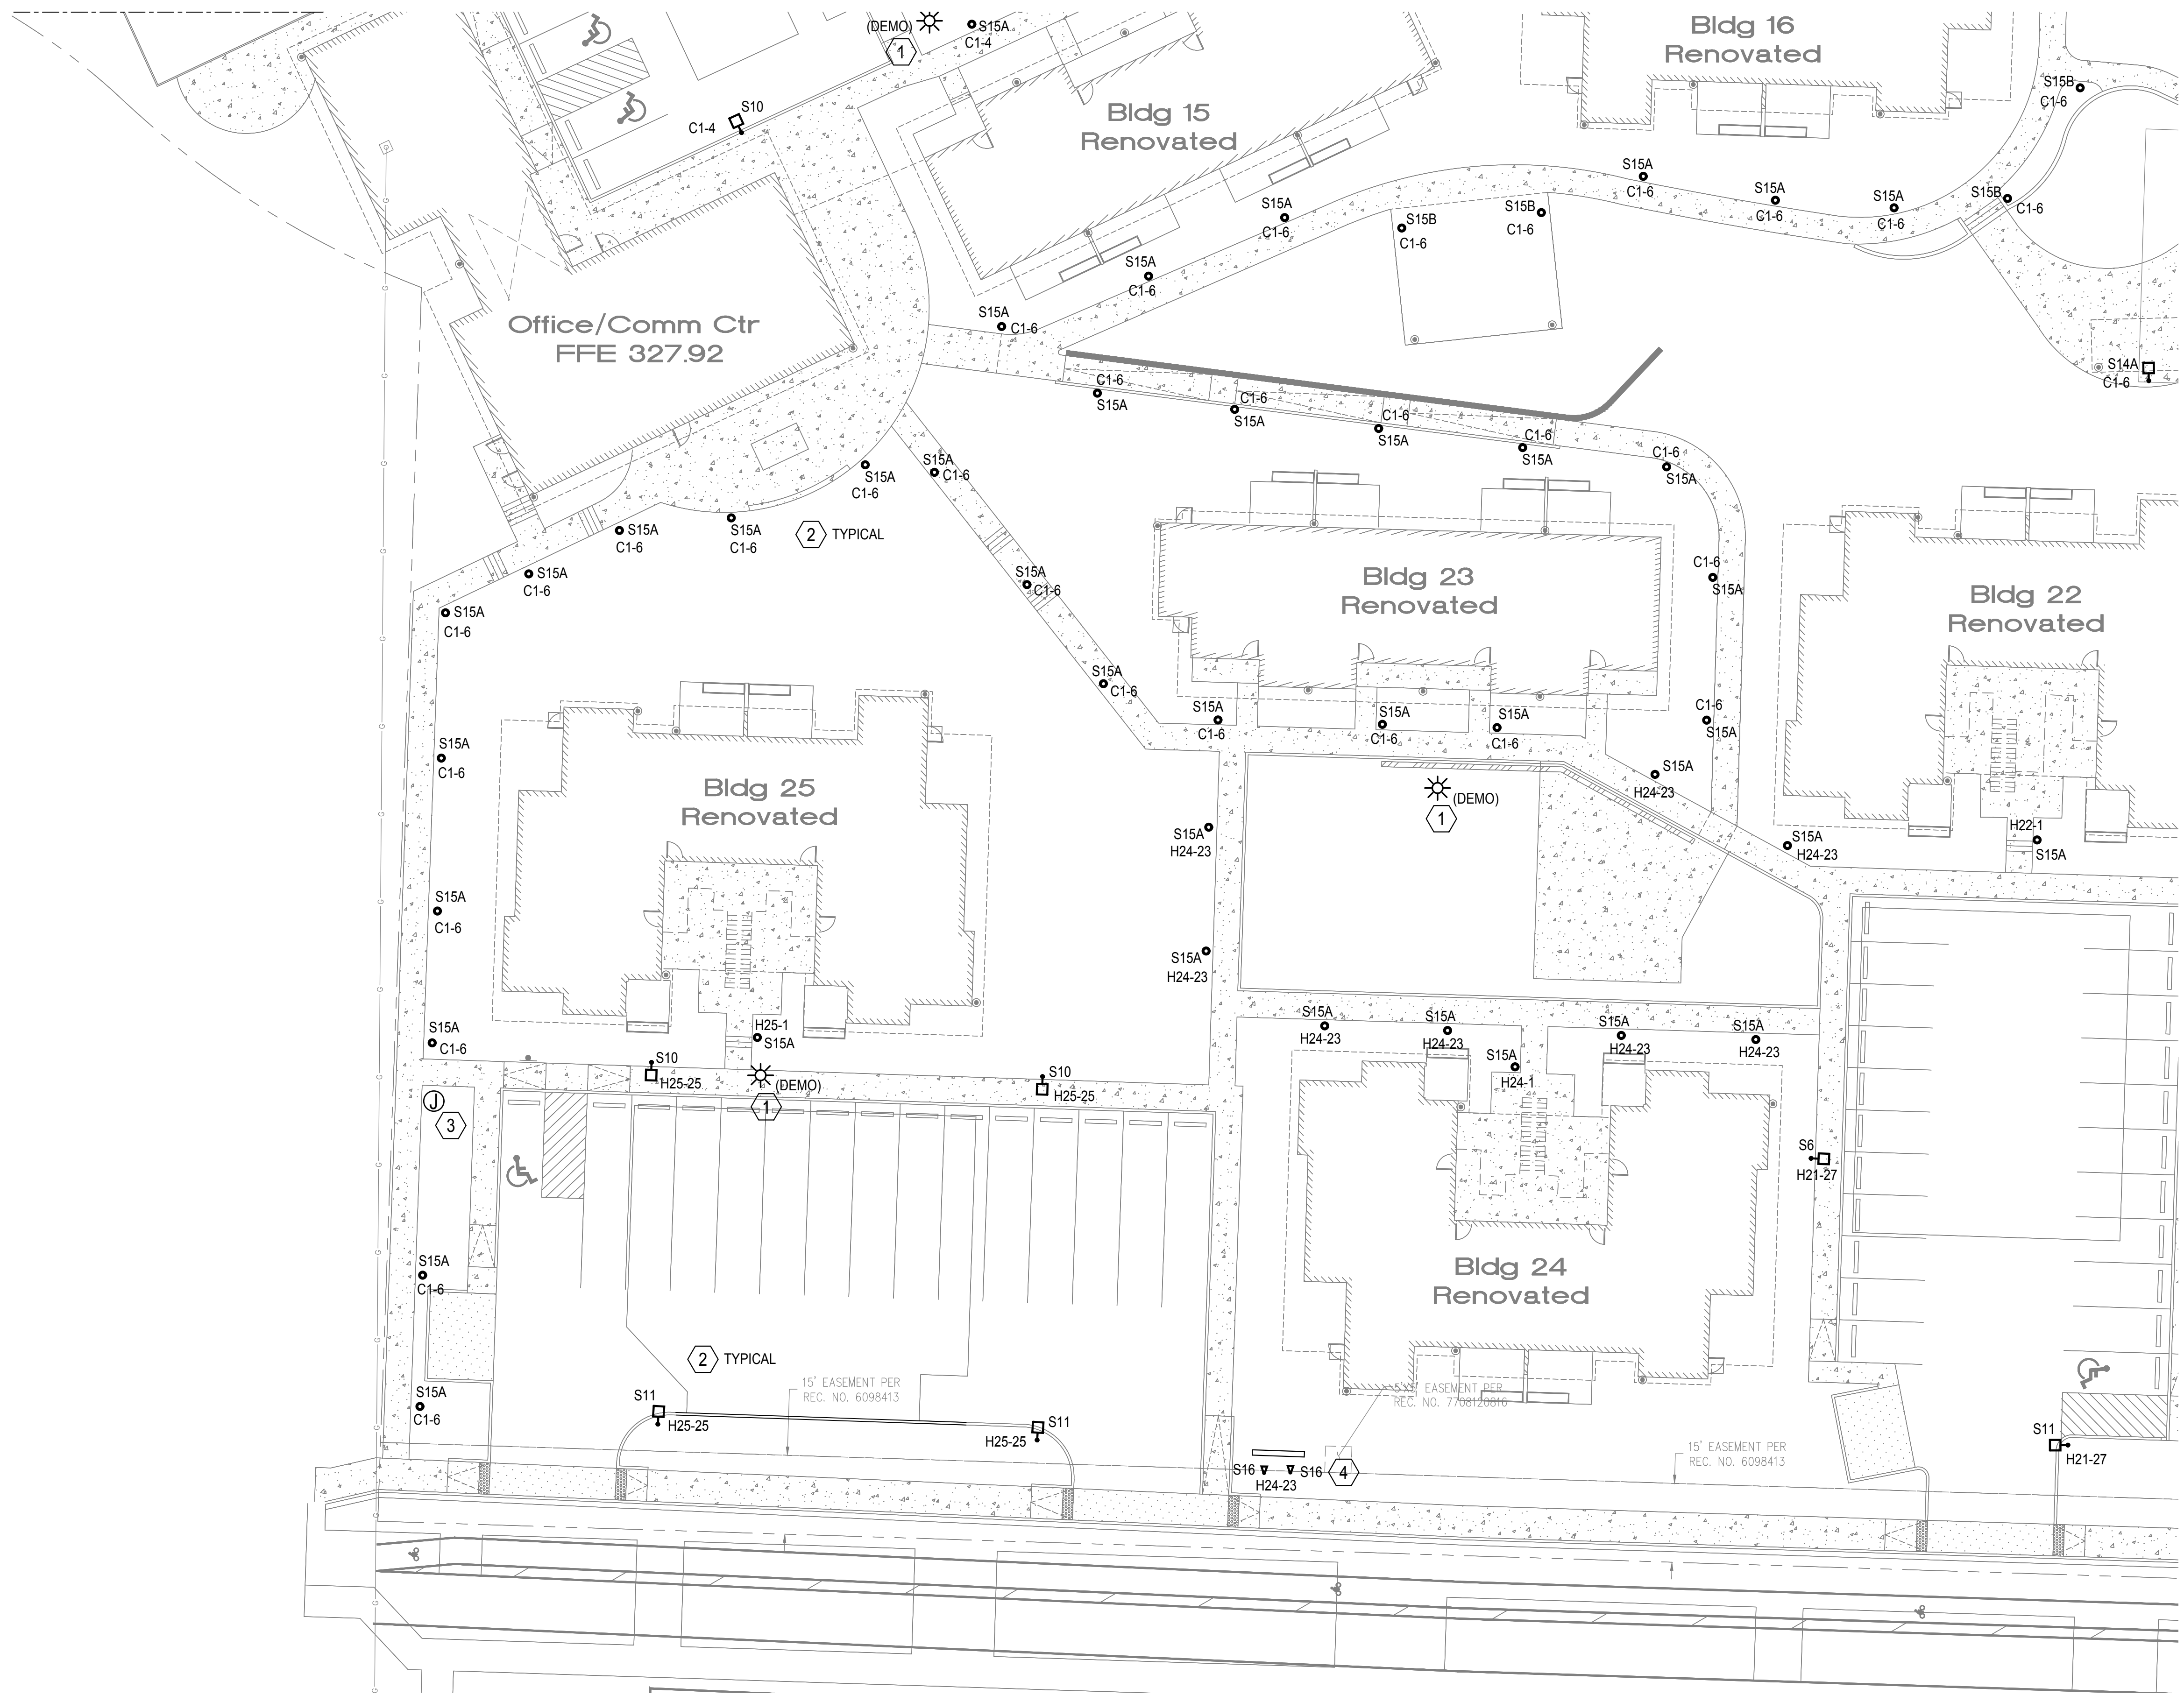

SITE LIGHTING PLAN - SECTION 5

SCALE: 1"=20'-0"

GENERAL NOTES:

- ALL POLE MOUNTED FIXTURES HAVE A MAX MOUNTING HEIGHT OF 20- FEET ABOVE GRADE PER CITY OF KIRKLAND REQUIREMENTS.
- MINIMUM WIRE SIZE FOR ALL SITE LIGHTING BRANCH CIRCUITRY TO BE #10 AWG COPPER. CONTRACTOR TO VERIFY VOLTAGE DROP ON CIRCUITS BASED ON FINAL FIXTURE PLACEMENT AND UPSIZE CONDUCTORS AS NECESSARY TO MEET CODE.
- PROVIDE IN-GRADE JUNCTION BOX AT EACH POLE MOUNTED AREA & ROADWAY LIGHT FOR BRANCH CIRCUIT CONNECTIONS TO POLE BASE.

FLAG NOTES (X):

- EXISTING LIGHT POLE TO BE DEMOLISHED. FEEDING BRANCH CIRCUIT CABLEING TO BE DEMOLISHED OR DISCONNECTED AND MADE SAFE WHERE ABANDONED IN PLACE.
- ALL NEW SITE LIGHTING FIXTURES TO HAVE AUTOMATIC TIMECLOCK ON/OFF ACTIVATION BY LIGHTING CONTROL PANEL (LCP) LOCATED IN THE BUILDING SERVING THE INDICATED BRANCH CIRCUITS. SEE INDIVIDUAL BUILDING DESIGN SHEETS FOR LCP RELAY SCHEDULE AND MORE INFORMATION.
- PROVIDE IN-GRADE JUNCTION BOX FOR EXTENDING LIGHTING BRANCH CIRCUIT TO FIXTURES LOCATED WITHIN DIFFERENT PHASES OF PROJECT CONSTRUCTION.
- GRADE MOUNTED FLOOR LIGHT(S) FOR MONUMENT SIGN(S). PROVIDE WEATHER-PROOF, IN-GRADE JUNCTION BOX, CAPABLE OF HOUSING THE LOW-VOLTAGE POWER SUPPLY FOR FIXTURES, WITH CONDUIT PATHWAY FROM J-BOX TO FIXTURE HEAD FOR CABLEING CONNECTIONS.